

HARRIMAN

 
AUBURN PORTLAND MANCHESTER

221 STATE STREET GENERATOR

West Campus  
Augusta, Maine


Harriman Project No. 15632

Key Plan



Issues and Revisions

Mark	Date	Description
	01-29-16	PROGRESS
	03-04-16	FINAL REVIEW
	03-09-16	CONSTRUCTION DOCUMENTS

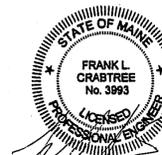


Drawing Scales

PA / PE: FLC  
Drawn By: PLS  
© 2016  
Harriman Associates

SITE PLAN


C00.1

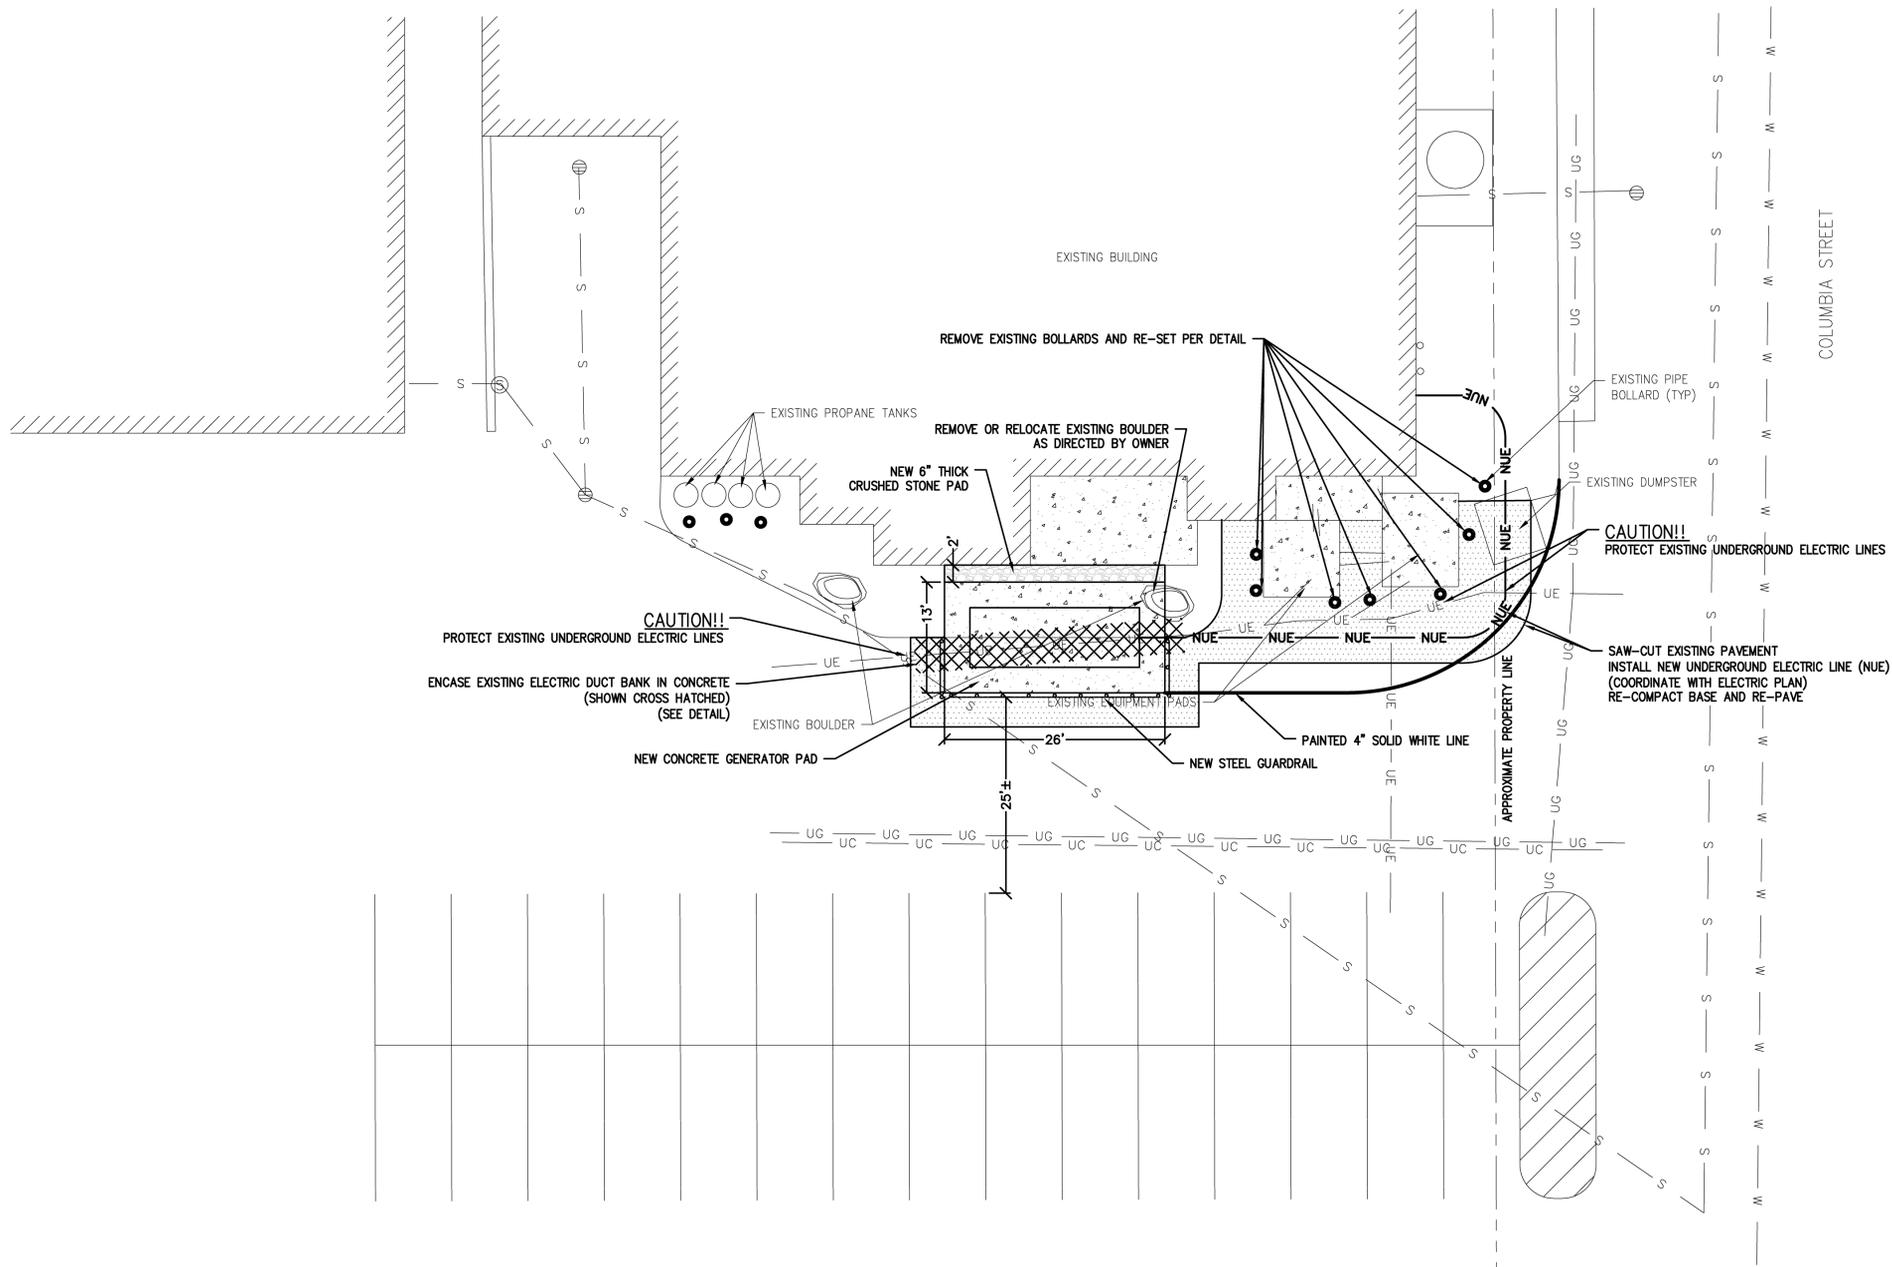

EXISTING DUCT BANK SECTION

NOT TO SCALE


C1

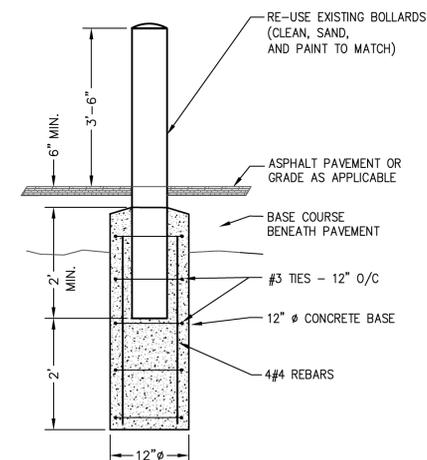

PIPE BOLLARD DETAIL

NOT TO SCALE

B1

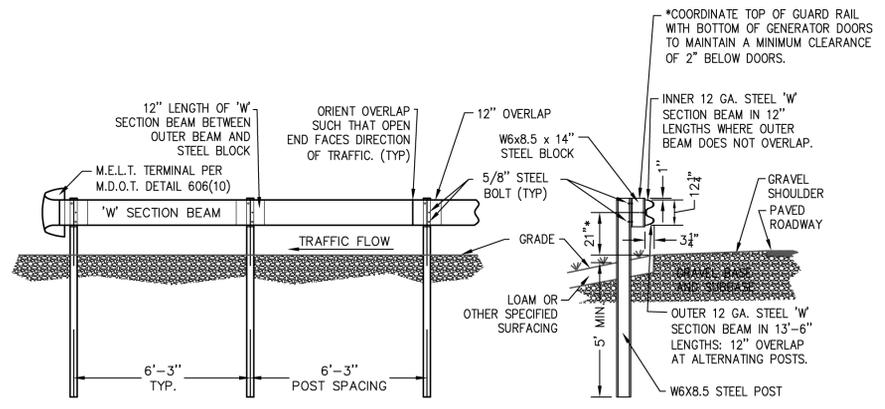

STEEL GUARDRAIL


NOT TO SCALE

A4

NEW DUCT BANK SECTION

NOT TO SCALE

A3

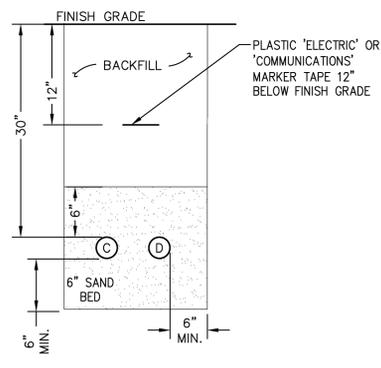

- NOTES:
1. CONDUITS AND WIRING SUPPLIED AND INSTALLED BY DIV. 26.
  2. NUMBER AND SIZE OF CONDUITS SHOWN ON ELECTRICAL PLANS


BITUMINOUS PAVEMENT DETAIL

NOT TO SCALE

A2

GENERATOR PAD

NOT TO SCALE

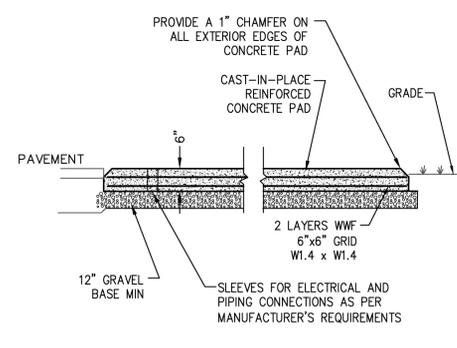

A1