

CURTIS HALL RENOVATIONS Maine Maritime Academy, Pleasant Street, Castine, Maine 04421



No. Date Description Revision Schedule


NOT FOR CONSTRUCTION

JOB NO. 076982

100% CONSTRUCTION DOCUMENTS -ISSUED FOR BIDDING 11/22/2023

TITLE ENVELOPE DETAILS


SHEET

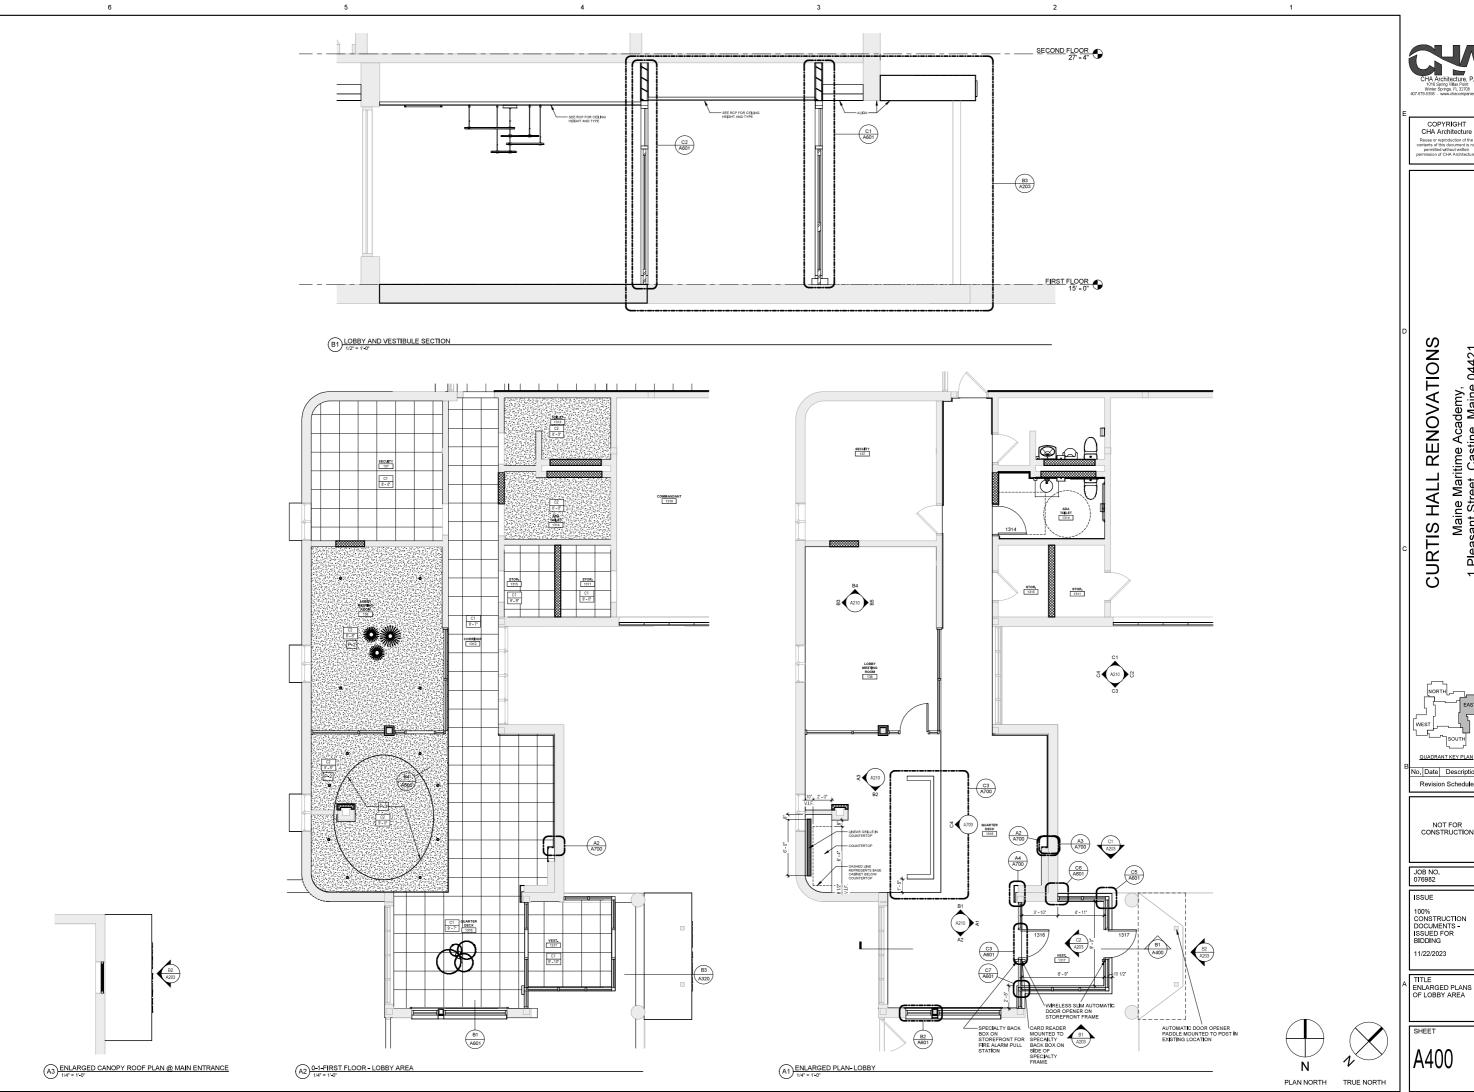

Maine Maritime Academy, Pleasant Street, Castine, Maine 04421

100% CONSTRUCTION DOCUMENTS -ISSUED FOR BIDDING

TITLE ENLARGED PLANS OF LOBBY AREA

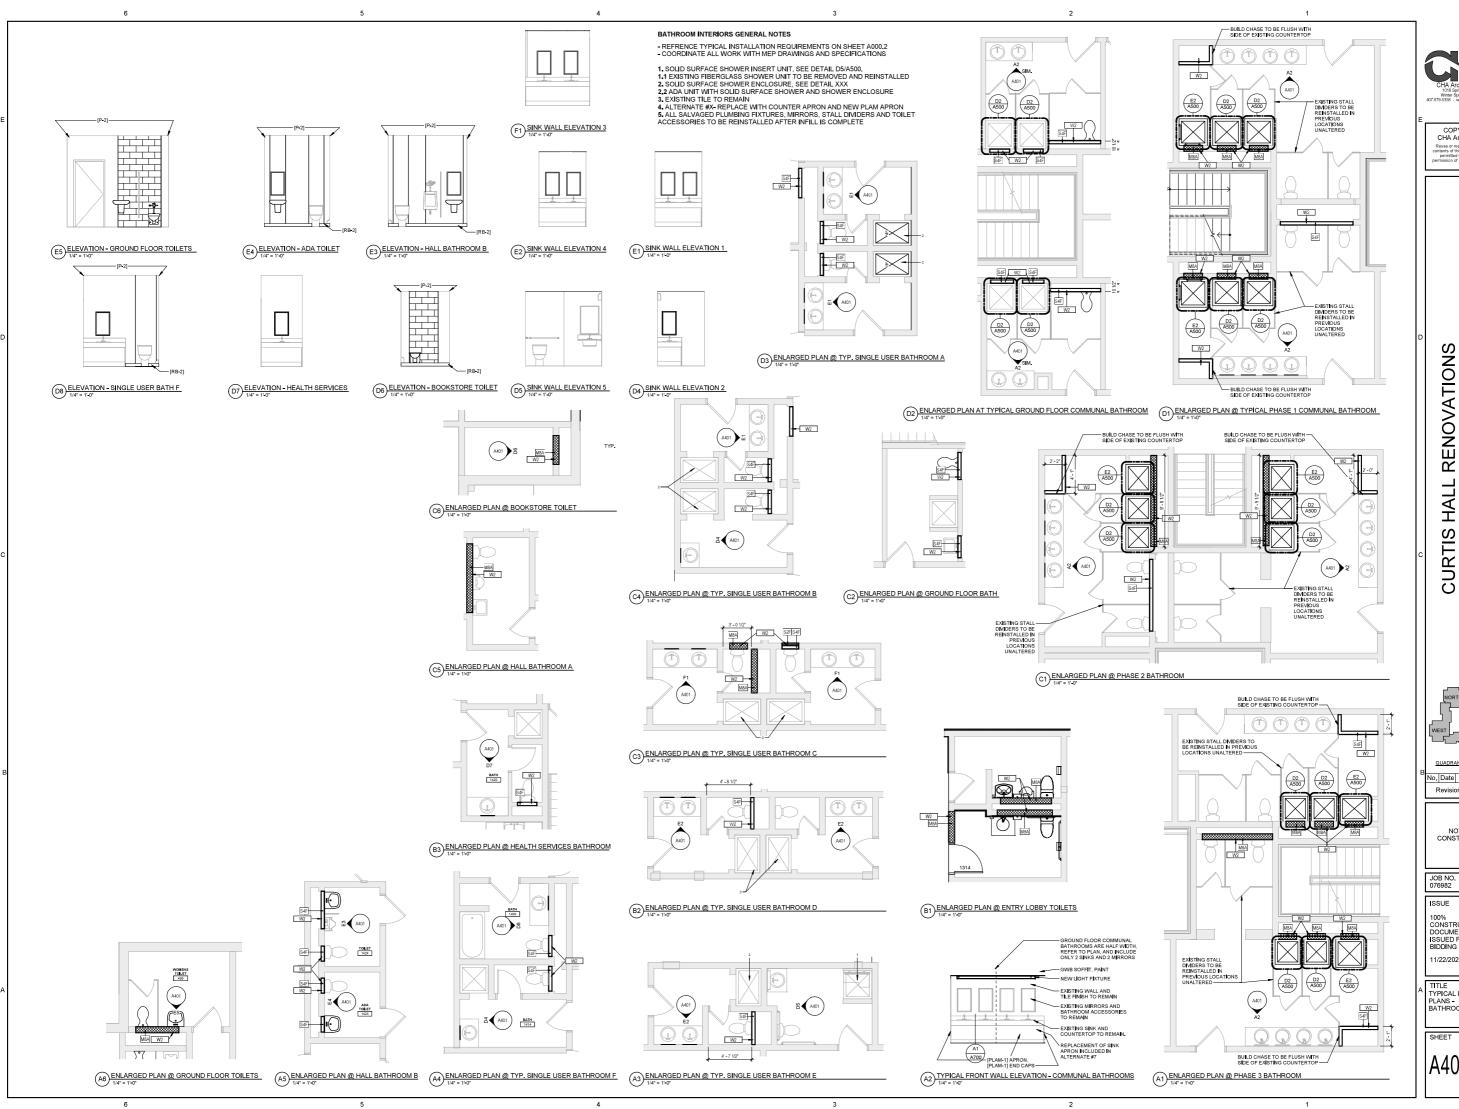

04421 Maine Maritime Academy, Pleasant Street, Castine, Maine


No. Date Description Revision Schedule

NOT FOR CONSTRUCTION


100% CONSTRUCTION DOCUMENTS -ISSUED FOR BIDDING 1/22/2023

TITLE TYPICAL ENLARGED PLANS -BATHROOMS

SHEET

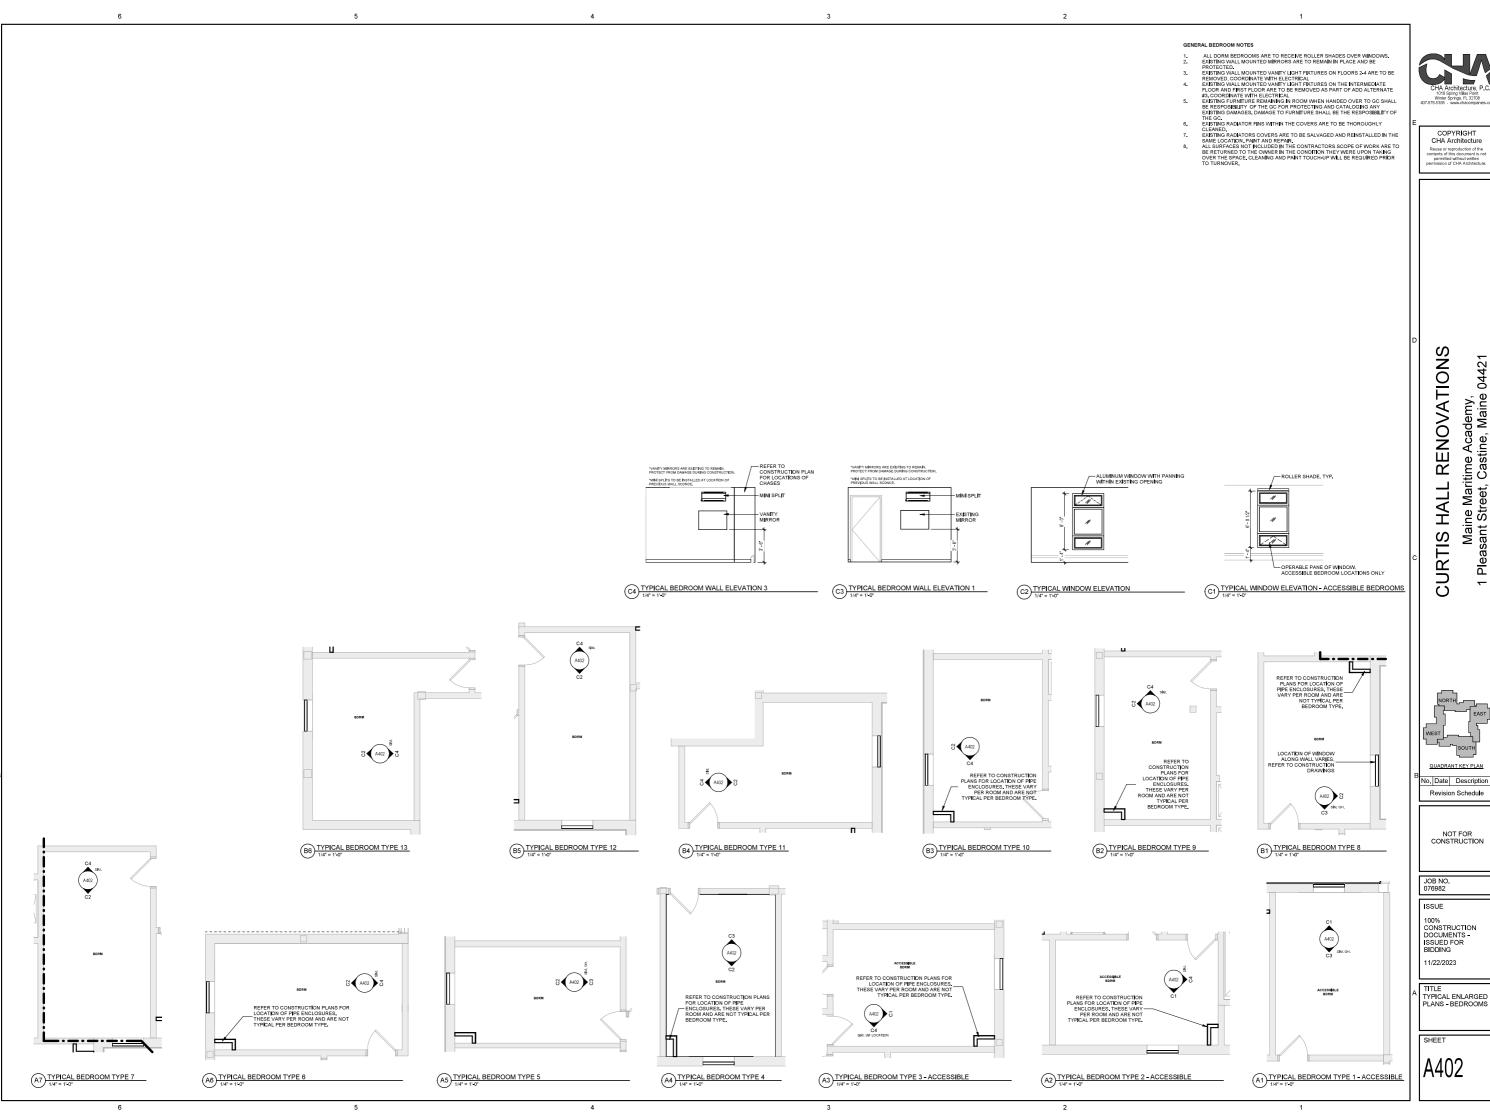



Maine Maritime Academy, Pleasant Street, Castine, Maine

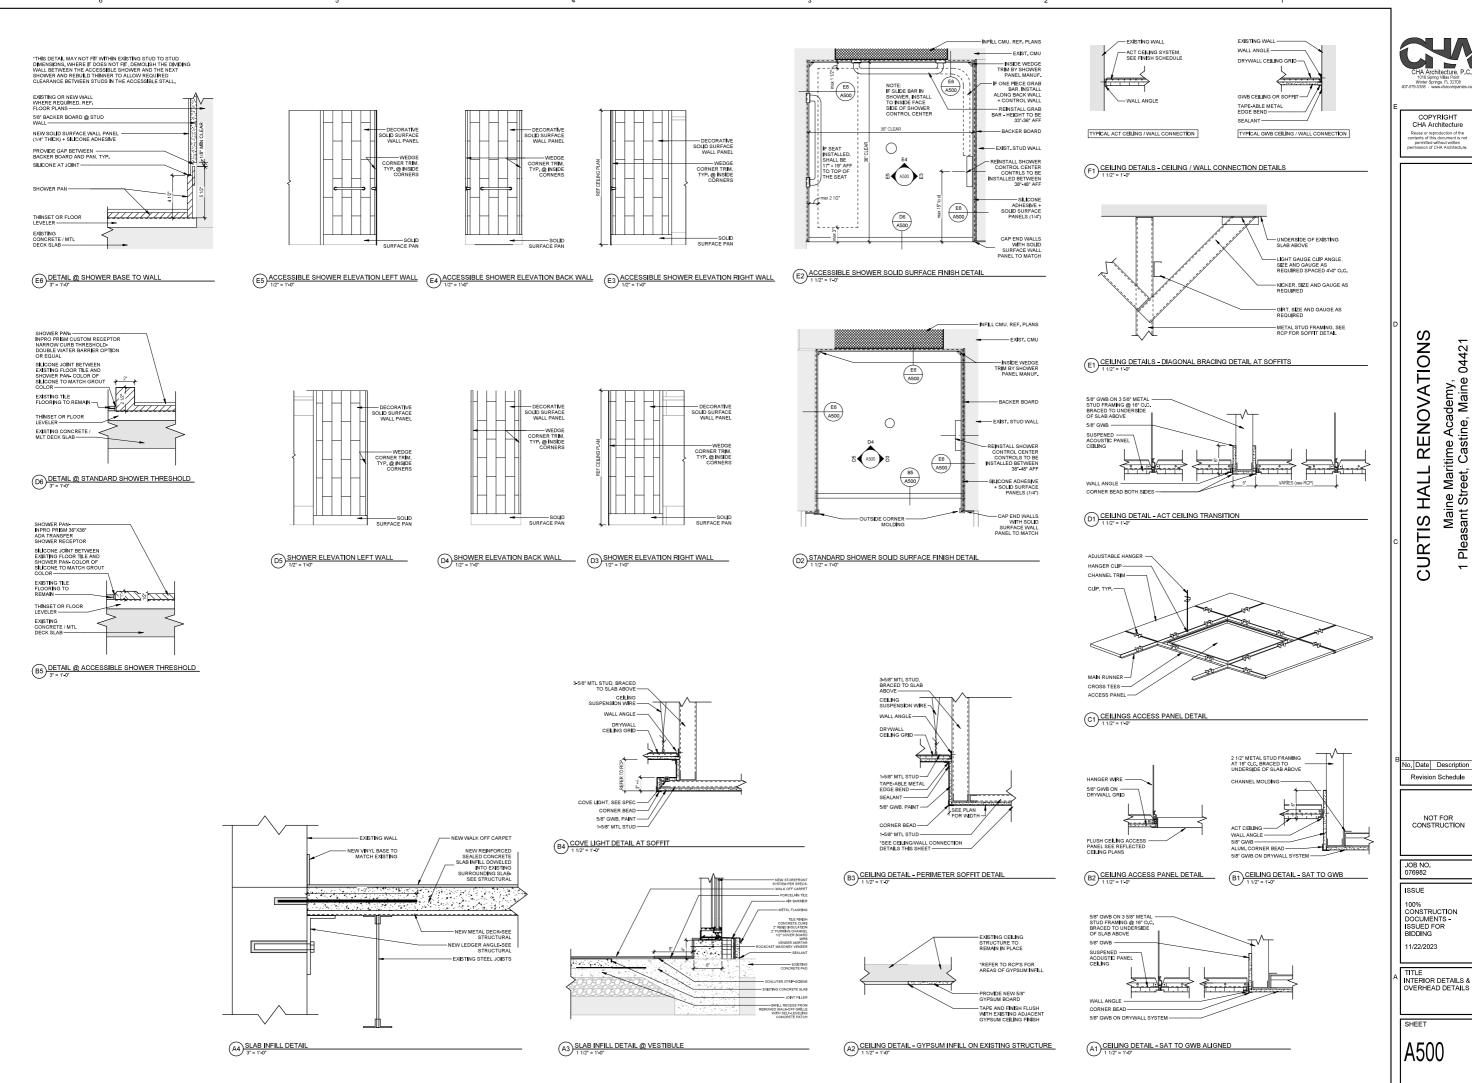

04421

Maine Maritime Academy, Pleasant Street, Castine, Maine

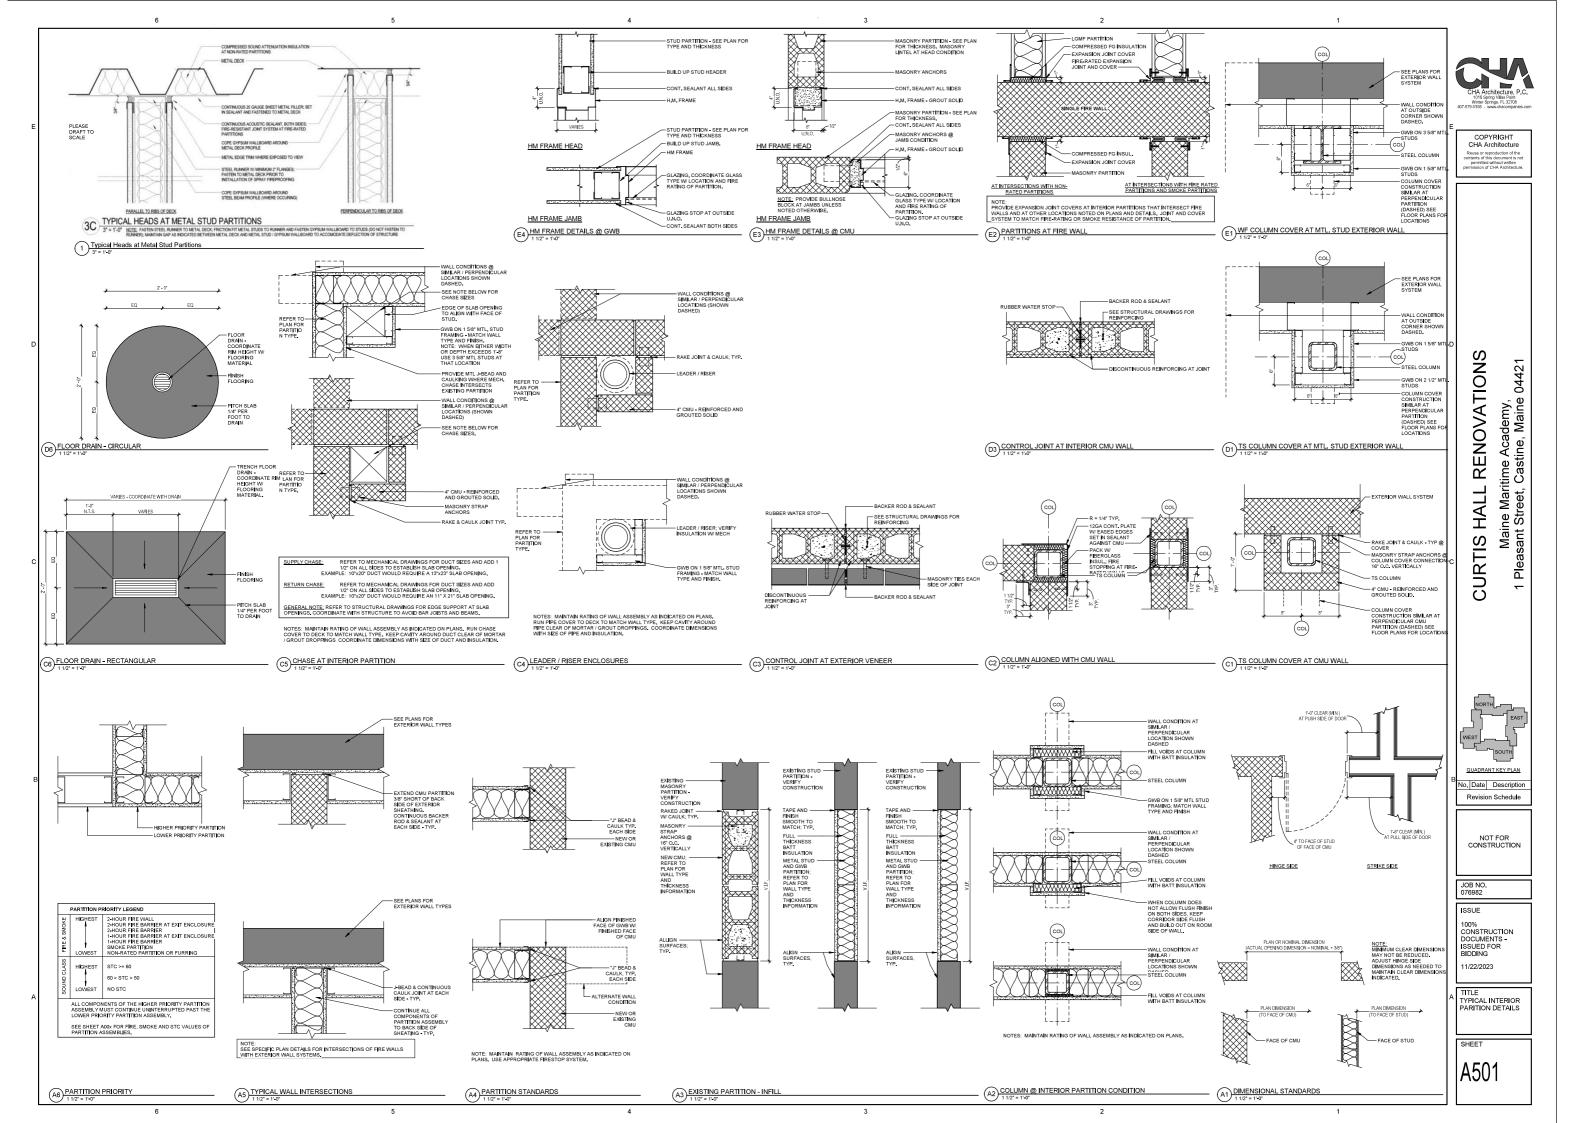

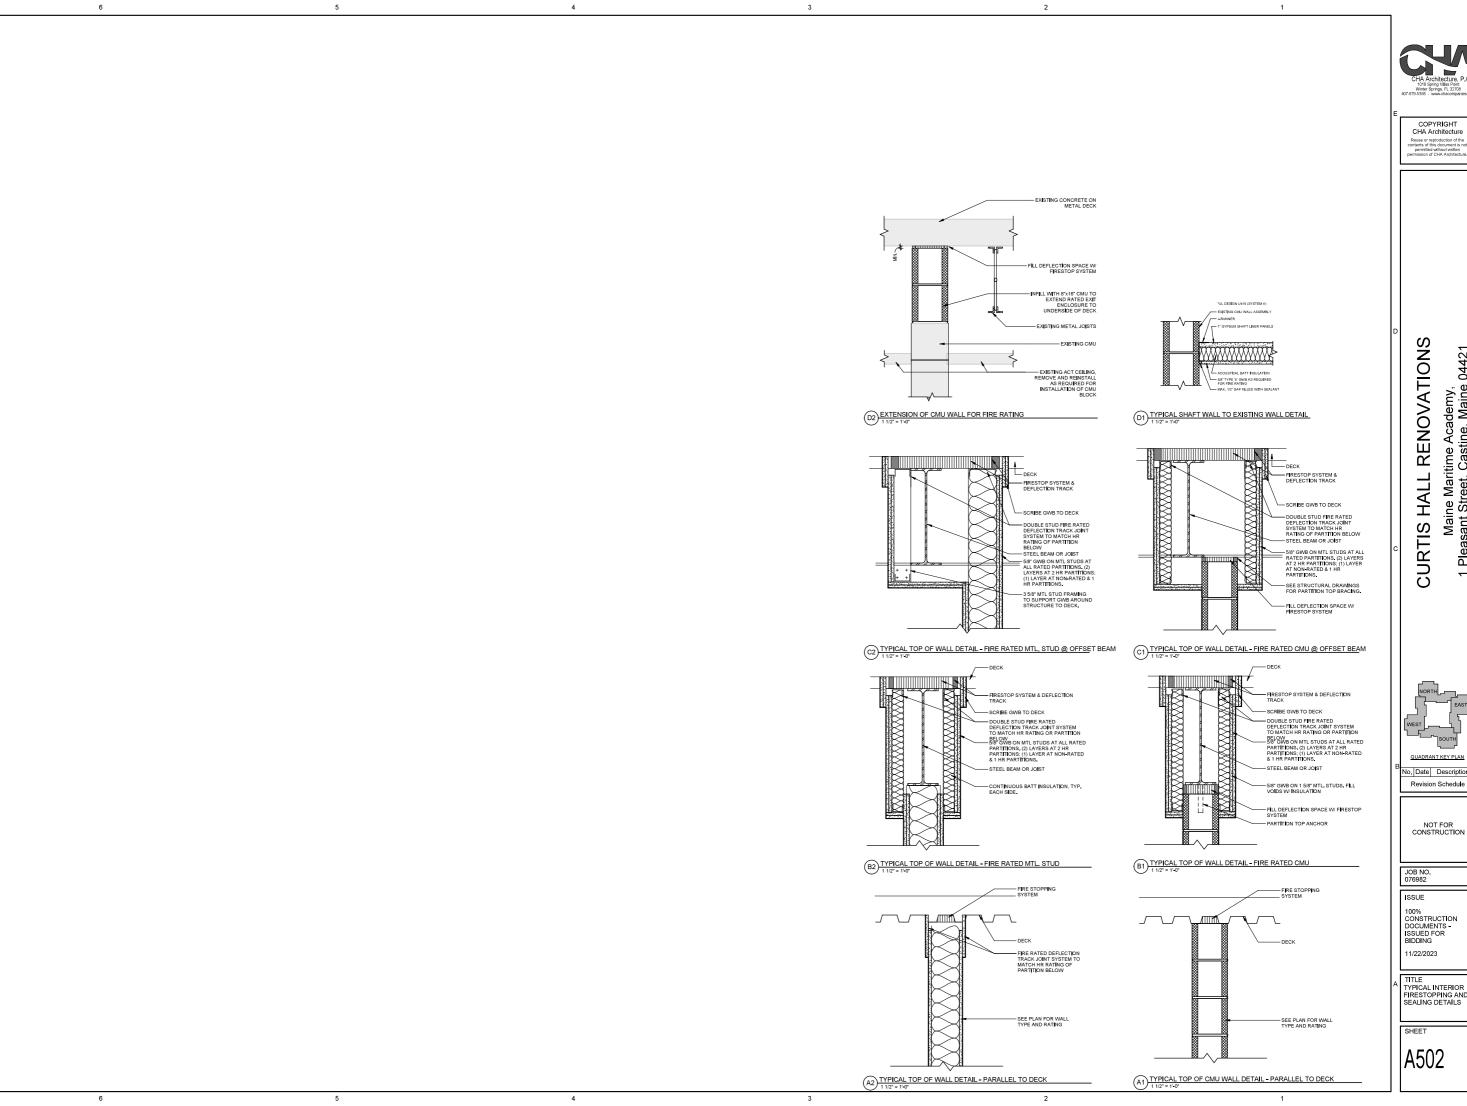

Maine Maritime Academy, Pleasant Street, Castine, Maine

04421

No. Date Description

NOT FOR CONSTRUCTION

JOB NO. 076982

ISSUE

100% CONSTRUCTION DOCUMENTS -ISSUED FOR BIDDING 11/22/2023

TITLE TYPICAL INTERIOR FIRESTOPPING AND SEALING DETAILS

SHEET

DOOR MARK NO. ROOM NAME OPERATION DOOR KEYNOTES: ALL EXISTING DOOR FRAMES ON EXTERIOR WHICH ARE TO REMAIN SHALL BE PREPPED, PRIMED AND PAINTED.
 DOORS AT COURTYARD SHALL BE PART OF ALTERNATE #4.
 SPROMDE CARD READER. 1 F C1) DOOR FRAME LEGEND 1/4" = 1'-0" DOOR ELEVATION LEGEND A2 A601 A1 A3 A601 A6 A601 A2 A601 A4 A601 A4 A601 A1 A601 2 - 8* A1 A601 A2 A601 A2 A601 A3 A601 A6 A601 A1 A601 2 - 8° A2 A601 A2 A601 A2 A601 A2 A601 A2 A601 W12 W10 B1 WINDOW ELEVATIONS
1/4" = 1'-0"



49 DARTMOUTH STREET PORTLAND, MAINE 04101 207-775-1059 www.chaarchitecture.com

COPYRIGHT CHA Architecture

Reuse or reproduction of the contents of this document is no permitted without written permission of CHA Architecture

CURTIS HALL RENOVATIONS

Maine Maritime Academy, 1 Pleasant Street, Castine, Maine 04421

No. Date Description Revision Schedule

NOT FOR CONSTRUCTION


JOB NO. 076982

100% DESIGN DEVELOPMENT

ISSUE 06/30/2023

TITLE DOOR, WINDOW, STOREFRONT SCHEDULES & TYPES

SHEET

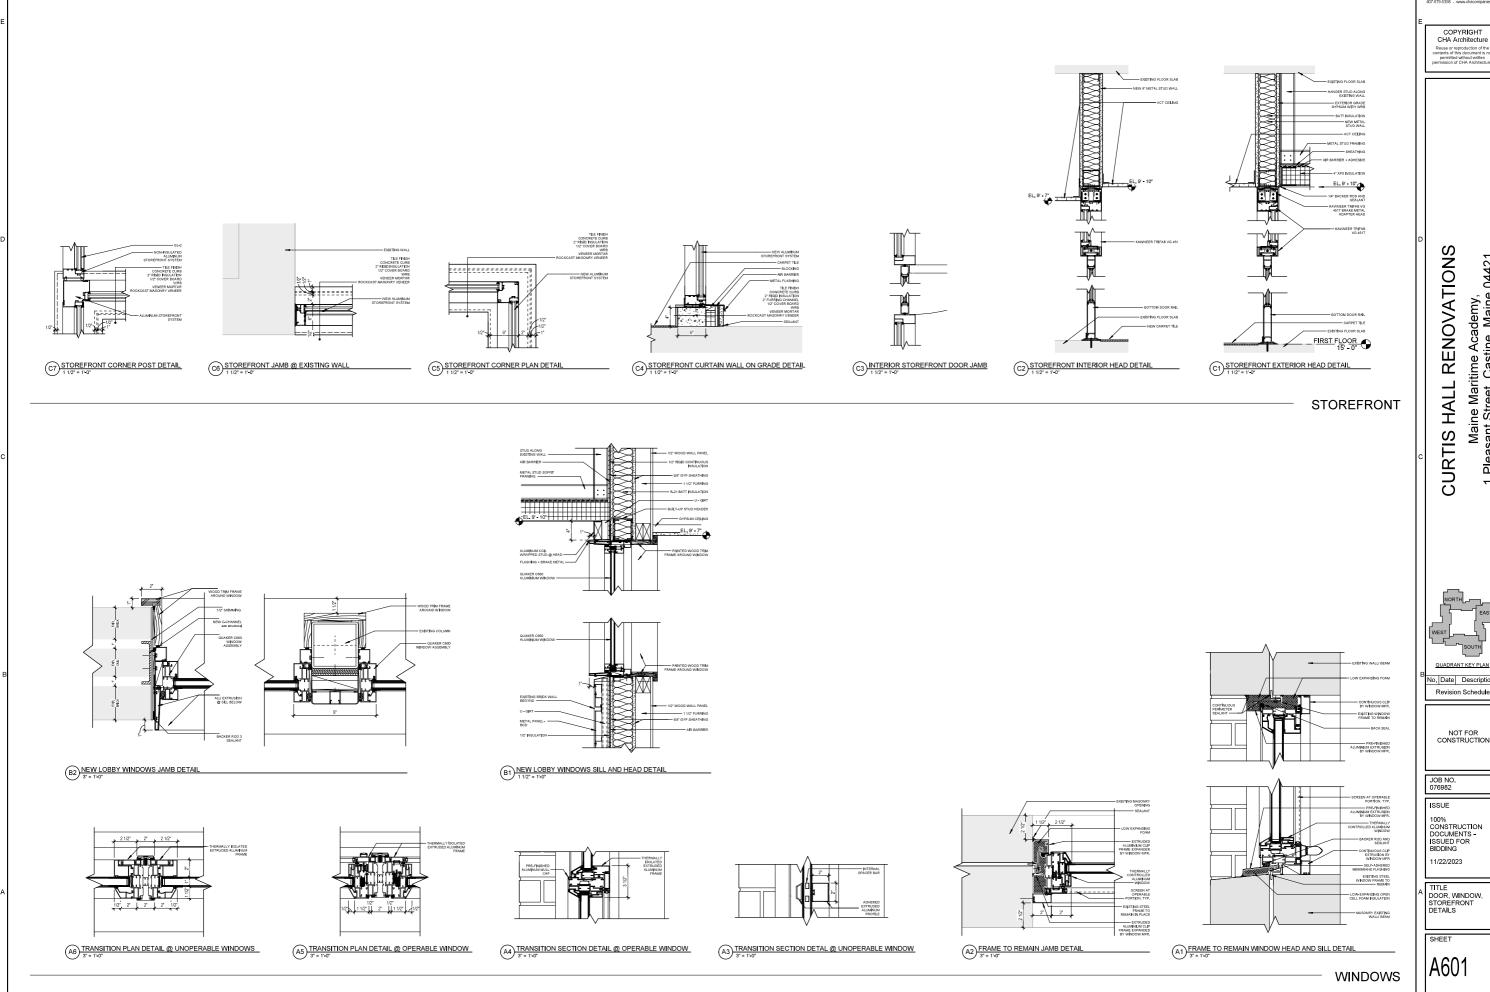


Maine Maritime Academy, Pleasant Street, Castine, Maine 04421

11/22/2023

TITLE DOOR, WINDOW, STOREFRONT DETAILS

SHEET

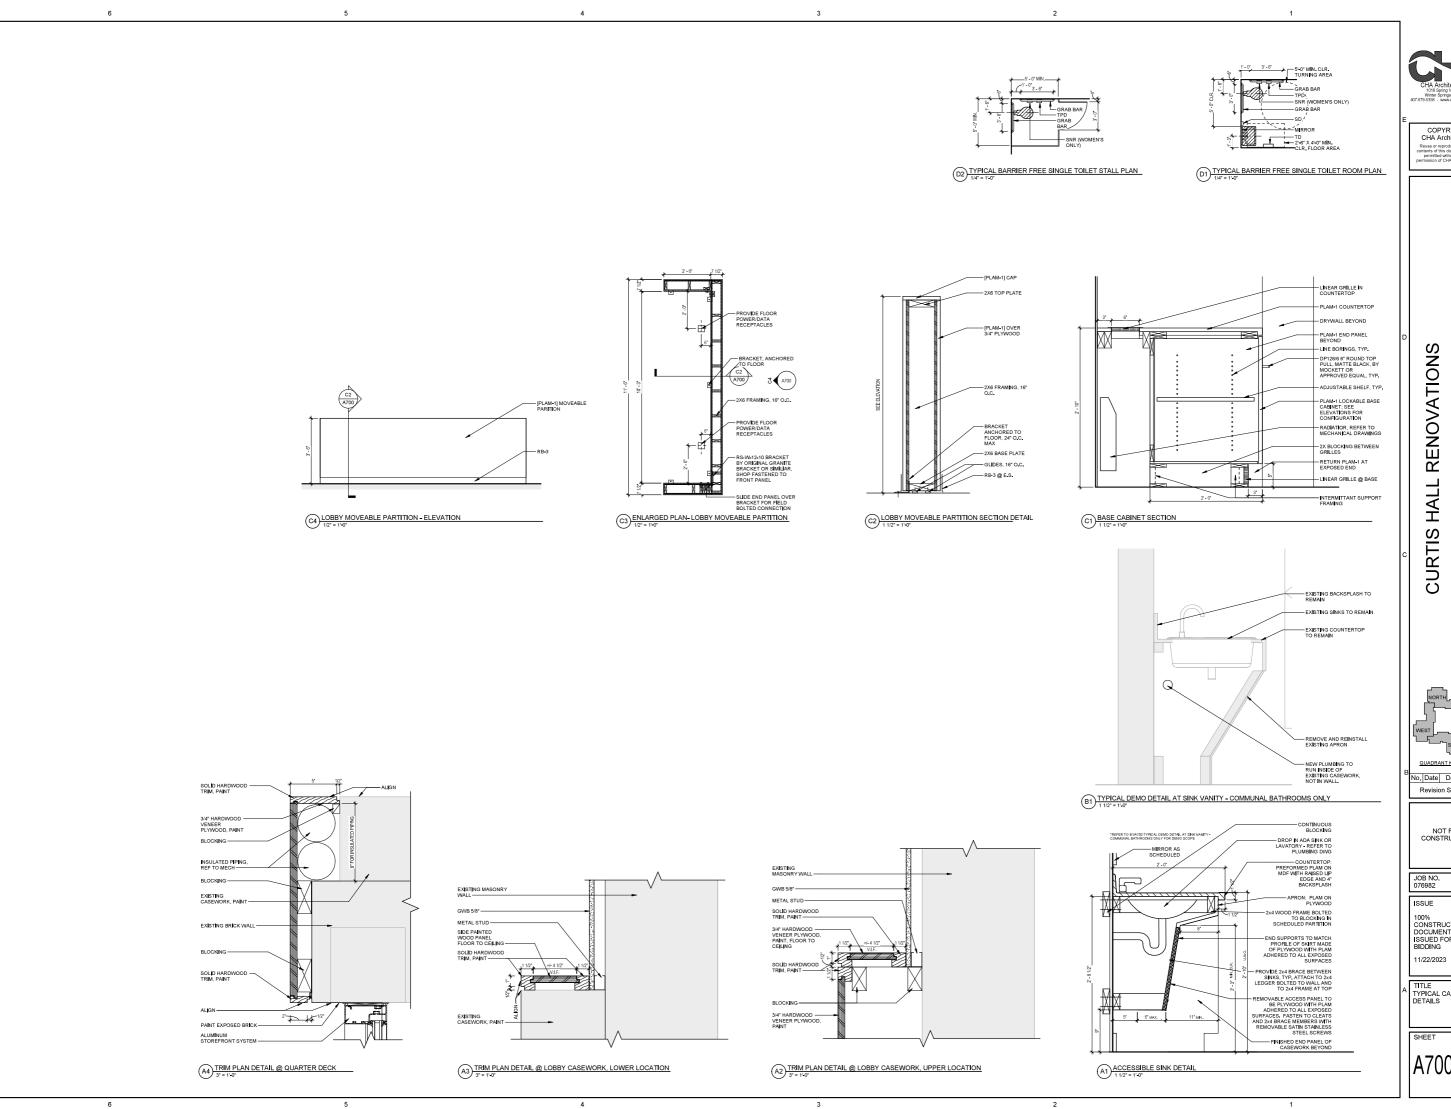

04421 Maine Maritime Academy, Pleasant Street, Castine, Maine

No. Date Description Revision Schedule

NOT FOR CONSTRUCTION

JOB NO. 076982

100% CONSTRUCTION DOCUMENTS -ISSUED FOR BIDDING

TITLE TYPICAL CASEWORK DETAILS


SHEET

- REFER TO FINISH PLAN AND SCHEDULE FOR ACCENT PAINT AT LOBBY
- REFER TO FINISH PLANS FOR FLOOR MATERIAL TRANSITIONS AND FOR FLOOR PATTERN PLANS.
- TILE MEMBRANE USED IN CONJUNCTION WITH FLOOR TILE (FT-1, FT-1), INSTALL; REFER TO SPECIFICATIONS
- PROVIDE FLOOR/WALL TRANSITION TRIM BETWEEN FLOOR AND WALL TILE; REFER TO SPECIFICATIONS
- 5. [P*] INDICATES ACCENT WALL COLORS
- REFER TO RCP FOR ACCENT PAINT COLORS
- 7. REFER TO FINISH PLANS FOR WALL FINISHES.

	Room Finish Schedule								
			BASE		WALLS				
NUMBER	ROOM NAME	FLOOR	MATL	N	S	E	W	NOTES	Department
1314	ADA TOILET	FT-2	WT-2	WT-1	P-5	P-5	P-5		FINISHES
1313	TOILET	FT-2	WT-2	WT-1, P-5	WT-1, P-5	WT-1, P-5	WT-1, P-5		FINISHES
1316	QUARTER DECK	FT-1, CPT-1	RB-1	P-1, P-2	P-1	P-1, P-4	P-1, P-3	SEE FINISH PLAN	FINISHES
1312	CORRIDOR	FT-1	RB-1	P-1, P-2	-	P-1	P-2	SEE FINISH PLAN	FINISHES
212	BDRM		RB-2	P-8	P-8	P-8	P-8		FINISHES
200.11	BATH		RB-2	P-8	P-8	P-8	P-8		FINISHES
1317	VEST.	MAT-1, FT-1	RB-1	P-1	P-1	P-1	P-1	SEE FINISH PLAN	FINISHES
138	LOBBY MEETING ROOM	CPT-2	RB-1	WC-1	P-1	WC-1	WC-1	SEE FINISH PLAN	FINISHES

	FINISH LEGEND						
TAG	DESCRIPTION	MANUFACTURER	MODEL	COLOR/PATTERN	NOTES		
PLAM-1	PLASTIC LAMINATE	ARBOR I TE	STANDARD HPL FINISH	WEATHERED ARCADIAN OAK			
WT-1	WALL TILE	NEMO TILE	METRO 2" X 8"	WHITE GLOSSY			
WT-2	WALL TILE	NEMO TILE	METRO COVE BASE 4" X 12"	WHITE GLOSSY			
WC-1	WALL COVERING	WOLF GORDON	RIDGELINE	SAND	USE WOLF GORDON RAMPART STRONGHOLD ON CMU BLOCK WALL		
FT-1	FLOOR TILE	NEMO TILE	BAROQUE 8" X 48"	NOGAL			
FT-2	FLOOR TILE	NEMO TILE	ROCCO 24"X24"	LIGHT MEDIUM- MATTE			
CPT-1	CARPET TILE	INTERFACE	NET EFFECT	NORTH SEA			
MAT-1	WALK OFF MAT	INTERFACE	STEP REPEAT	SR699 MIDNIGHT			
P-1	PAINT	BENJAMIN MOORE	EGGHELL	CLASSIC GRAY 1548			
P-2	PAINT	BENJAMIN MOORE	EGGHELL	NORMANDY 2129-40			
P=3	PAINT	BENJAMIN MOORE	EGGHELL	NEW HOPE GRAY 2130-50			
P-4	PAINT	BENJAMIN MOORE	EGGHELL	MARBLEHEAD GOLD HC11			
P-5	PAINT	BENJAMIN MOORE	SEM F GLOSS	CHANTILLY LACE			
P-6	PAINT	BENJAMIN MOORE	EGGHELL	-	MATCH EXISTING PAINT- ARCHITECT TO SELECT COLOR		
P-7	PAINT	BENJAMIN MOORE	FLAT	CEILING WHITE			
P-8	PAINT	SHERWIN WILLIAMS	EGGSHELL- PRO MAR 200	CROCKERY WHITE	EXISTING PAINT COLOR PROVIDED BY OWNER		
P-9	PAINT	SHERWIN WILLIAMS	DTM ACRYLIC COATING	GLOSS BLACK	EXISTING PAINT COLOR PROVIDED BY OWNER		
P-10	PAINT	SHERWIN WILLIAMS	FLAT	CEILING WHITE	EXISTING PAINT COLOR PROVIDED BY OWNER		
RB-1	RESILIENT BASE	JOHNSON I TE	4" BASE	GREY HAZE			
RB-2	RESILIENT BASE	JOHNSON I TE	4" BASE	VAPOR GREY			
RB-3	RESILIENT BASE	JOHNSON I TE	4" BASE	BEIGE WB			
G-1	GROUT	LATICRETE	PERMACOLOR GROUT	-	ARCHITECT TO SELECT COLOR		
G-2	GROUT	LATICRETE	PERMACOLOR GROUT	-	ARCHITECT TO SELECT COLOR		
G-3	GROUT	LATICRETE	PERMACOLOR GROUT	-	ARCHITECT TO SELECT COLOR		
WP-1	TACKABLE SURFACE	CARNEG I E	XOREL	METEOR 6427			
WB-1	WHITE BOARD	CLAIRIDGE	GLASS WALL MOUNTED	TBD	ARCHITECT TO SELECT COLOR		
C-1	ACOUSTIC CEILING TILE	ARMSTRONG	CALLA	CALLA SQUARE LAY IN #2821 2' x 4', 15/16" GRID			
TS-1	FLOOR TRANSITION	SCHLUTER	SCHIENE				
TS-2	FLOOR TRANSITION	CORIAN	SOLID SURFACE	SILVER GREY			
CJ	FLOOR CONTROL JOINT	SCHLUTER	DILEX-BWS	STAINLESS			

MISC. ACCESSORIES LEGEND						
DESCRIPTION	MANUFACTURER	MODEL	COLOR/PATTERN			
GROMMETS	MOCKETT	MFG1/B	NICKEL (17)			
CARINET DULL C	MOOKETT	DD128/6 6 11/16*	MATTE BLACK			

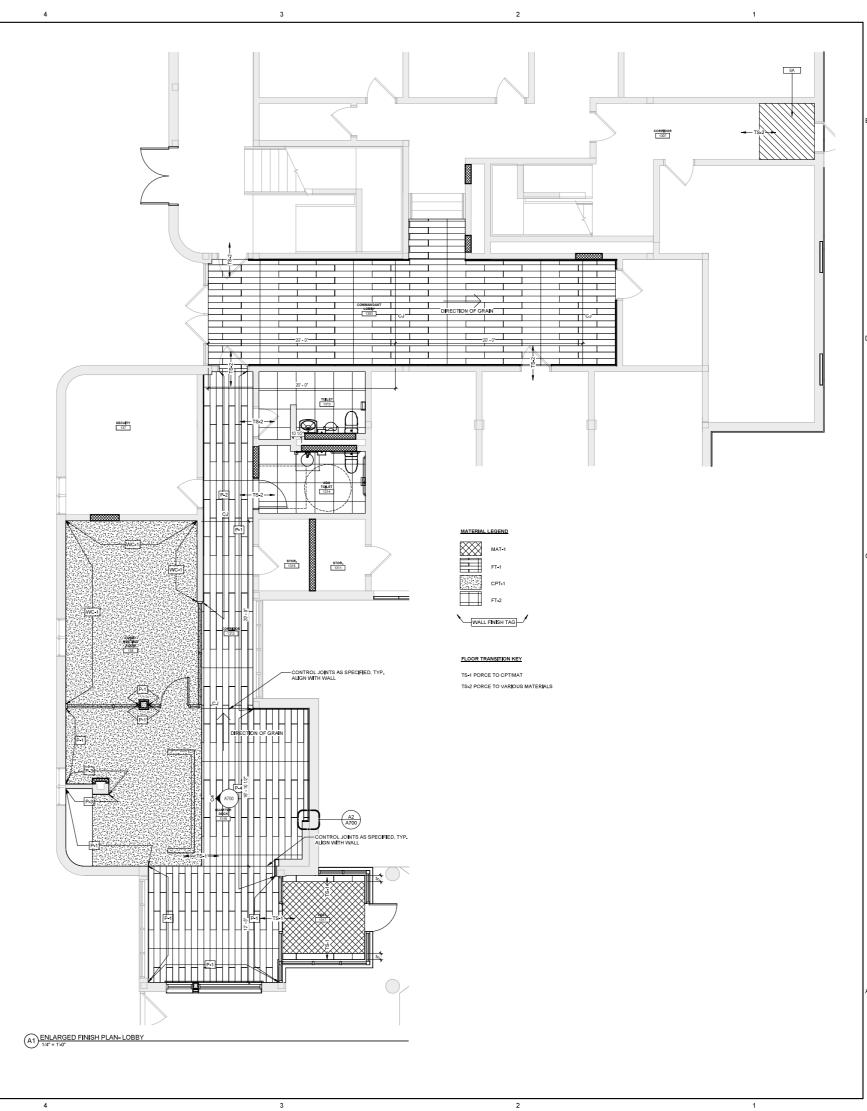

CURTIS HALL RENOVATIONS

Maine Maritime Academy, Pleasant Street, Castine, Maine 04421

No. Date Description Revision Schedule

NOT FOR CONSTRUCTION

JOB NO. 076982

ISSUE

100% CONSTRUCTION DOCUMENTS -ISSUED FOR BIDDING 11/22/2023

TITLE FINISH PLANS FINISH SCHDULES AND NOTES

SHEET

DISCREPANCIES BETWEEN THE ABOVE LISTED CODES AND THE CONSTRUCTION DOCUMENTS SHALL BE BROUGHT TO THE ATTENTION OF THE ENGINEER FOR CLARIFICATION BEFORE PROCEEDING WITH AFFECTED WORK. WORK SHALL BE PERFORMED BY PERSONS QUALIFIED IN THEIR TRADE AND LICENSED TO PRACTICE SUCH TRADE IN THE STATE IN WHICH THE PROJECT IS LOCATED,

THESE DRAWINGS SHALL BE USED IN CONJUNCTION WITH ANY ARCHITECTURAL, MECHANICAL, AND ELECTRICAL DRAWINGS IN ADDITION TO ANY SPECIFICATIONS AND ANY SHOP DRAWINGS PROVIDED BY SUBCONTRACTORS AND SUPPLIERS,

DIMENSIONS, ELEVATIONS, AND CONDITIONS SHALL BE VERIFIED IN THE FIELD BY THE GENERAL CONTRACTOR (GC) AND DISCREPANCES SHALL BE REQUEST TO THE ATTENTION OF THE ENGINEER FOR CLARIFICATION BEFORE PROCEEDING WITH THE AFFECTED PART OF WICK.

UNLESS OTHERWISE NOTED, DETAILS, SECTIONS, AND NOTES SHOWN ON THESE DRAWINGS SHALL BE CONSIDERED TYPICAL FOR SIMILAR DETAILS,

SHOP DRAWINGS PROVIDED BY OTHERS SHALL BE SUBMITTED TO THE ENGINEER FOR REVIEW PRIOR TO THE FABRICATION OF MATERIAL OR THE PURCHASE OF NON-REFUNDABLE STOCK, DIMENSIONAL REVIEW IS THE GC'S RESPONSIBILITY.

TEMPORARY BRACING OR SHORING WHICH IS NEEDED TO HOUD THE STRUCTURE IN A SAFE AND STARLE POSITION UNTIL IT IS COMPLETE. IS SOLELY THE RESPONSIBILITY OF THE GOT, THE GOT SHALL IS ISSUIT COMPLETE SHORING PLANS AND DETAILS PREPARED BY A REGISTERED PROFESSIONAL ENGINEER SPECIALIZING IN SHORING STRUCTURES, TO BE REVIEWED BY THE ENGINEER OF RECORD PRIOR TO THE START OF EDICULTION OR CONSTRUCTION ACTIVITIES.

THE BUILDING PERINT APPLICANT (E.G. CONTRACTOR) MUST PROVIDE SPECIAL INSPECTIONS PER THE REQUIREMENTS OF CHAPTER 17 OF THE 21St BIG AND FURNISH INSPECTION REPORTS TO THE CODE OFFICIAL AND TO THE ENGINEER OF RECORD. THE TESTIMONISPECTION AGENCY (SIN MUST BE APPROVED BY THE CHAPTER OF RECORD.

THE ENGINEER, AT HISHER OPTION, MAY PROVIDE THE GOWINGER OF REQUENT.

THE ENGINEER, AT HISHER OPTION, MAY PROVIDE THE GC WITH ELECTRONIC FILES FOR HISHER COWENIBRICE AND USE IN THE
PREPARATION OF SHOP DRAWINGS. DATA CONTAINED ON THESE ELECTRONIC FILES ARE THE ENGINEER'S INSTRUMENT OF SERVICE
AND MAY HOT BE ELECTRONICALLY COPED FOR REUSE AS SHOP DRAWINGS. FURTHERMORE THESE SLEED HERE NOT
CONSTRUCTION DOCUMENTS AND THEREOFY. THE GIS IN FOR ELEVINE OF HISHER DUTY TO FILLY COMPLY WITH THE CONSTRUCTION
CONSTRUCTION OF HIGH THE PROVIDED HERE OF THE PROVIDED HERE OF THE CONTRACT OF THE PROVIDED.

THE DISCONLINE OF THE PROVIDED HERE OF THE PROVIDED HERE OF THE PROVIDED. THE PROVIDED HERE OF MAY NOT MANUALLY ALTER THE HARD COMES OF THE CONSTRUCTION DOCUMENTS AND REUSE THEM AS SHOP
DRAWINGS.

DESIGN LOADS:

THE PROPOSED STRUCTURAL ELEMENTS FOR THE STORE HAVE BEEN DESIGNED IN ACCORDANCE WITH THE 2015 IBC TO CARRY ALL

THE DEAD LOADS OF THE VARIOUS STRUCTURAL AND ARCHITECTURAL SYSTEMS AND THE FOLLOWING LIVE LOADS:					
RISK CATEGORY	III				
<u>DEAD LOAD</u>					
EQUIPMENT DL	PER PLAN				
SNOW LOAD					
BASIC GROUND SNOW LOAD THERMAL FACTOR EXPOSURE FACTOR IMPORTANCE FACTOR FLAT ROOF SNOW LOAD SNOW DRIFT LOADS	P ₁ = 60 PSF C ₁ = 1.0 C ₂ = 1.0 I ₃ = 1.1 P ₁ = 46,2 PSF PER PLAN				
WIND					
BASIC WIND SPEED EXPOSURE CATEGORY	V _{ULT} = 122 MPH C				
SEISMIC					
SITE CLASS IMPORTANCE FACTOR SPECTRAL ACCELERATIONS SEISMIC DESIGN CATEGORY	D (ASSUMED) I _E = 1.25 Sos = 0.199, Sor = 0.113 B				

BEDDING AND FILL PROFILES BENEATH SLASS ON GRADE AND FOUNDATION FOOTINGS SHALL COMPLY WITH THE RECOMMENDATIONS PROVIDED IN THE GESTECHNICAL REPORT REFERENCED ABOVE, ALL FOOTING SOTTOMS SHALL SE INSPECTED AND APPROVED, IN WITHING, BY A REGISTERED SOLLS ENGINEER PRIOR TO PLACING CONCRETE. WRITTEN APPROVAL SHALL SPECIFY THAT THE SOLL WAS THE CAMPITY TO SUPPORT THE DESIGNED BEARING PRESSURE;

FOUNDATION DESIGN IS BASED ON SHALLOW SPREAD FOOTINGS BEAPING ON SUITABLE UNDISTURBED NATIVE SOILS ANDICR NEW COMPACTED GRANULARSTRUCTURAL FILL AS PROVIDED IN THE GEOTECHNICAL REPORT REFERENCED ABOVE EXTEDNING TO UNDISTURBED NATIVE SOILS, REFER TO THIS REPORT FOR SPECIFIC BEARING RECOMMENDIATIONS.

EXTERIOR STRIP AND SPREAD FOOTINGS SHALL HAVE MINIMUM 4'-6' GRADE COVER TO BOTTOM OF FOOTING ELEVATIONS.

REFERENCE THE GEOTECHNICAL REPORT FOR ALL EXCAVATION, BACKFILL, COMPACTION, CONSTRUCTION DEMATERING AND PERMANENT DRAINAGE REQUIREMENTS.

SOILS EXPOSED AT THE BASE OF ALL SATISFACTORY FOUNDATION EXCAVATIONS SHALL BE PROTECTED AGAINST ANY DETRIMENTAL CHANGE IN CONDITION SUCH AS DISTURBANCE FROM RAIN OR FROM S. DIRFACE RUNGET SHALL BE DRAINED AWAY FROM THE EXCAVATIONS AND TO BE ALLOWED TO POIN, FOUNDATION DECOVATIONS SHALL BE ADDIVINGTHE PROTECTED FROM RAIFFALD RE-EXCAVATIONS AND TO BE ALLOWED TO POIN, FOUNDATION DECOVATIONS AND APPROPRIATE DEVIATERING MEASURES SHALL BE BIRLY CHE.

SLABS ON GRADE SHALL BEAR ON A MINIMUM OF 12" OF COMPACTED STRUCTURAL FILL OR F OF CRUSHED STONE. IF LOOSE OR UNDESPRACE FILLS ARE DISCONTERED AT THE SLAB SUBGRADE LEVEL, THEY SHALL BE OVER EXCAMATED TO THE SURFACE OF THE INTURAL, SOIL, AND REPLACED WITH COMPACTED STRUCTURAL FILL OR CRUSHED STOVE, REFER TO ARCHITECTURAL DRAWNOSS FOR VAPOR BARRIER AND INSULATION REQUIREMENTS, MICHST CURE SLASS IN ACCORDANCE WITH A CI.

GRADATION AND USAGE FOR CRUSHED STONEISTRUCTURAL FILL AND GRANULAR BORROW FILL MATERIALS SHALL BE AS NOTED IN THE GEOTECHNICAL REPORT.

STRUCTURAL FILL OR GRANULAR FILL BENEATH SLABS SHALL BE PLACED IN LAYERS NOT EXCEEDING 12 INCHESIN LOOSE NEASURE AND COMPACTED BY SELF-ROPELLED COMPACTED BY SELF-ROPELLED COMPACT TO A DRY DELISTOR OF A LEST SHAP OF THE MOUNT OF A LEST SHAP THE MOUNT OF A LEST SHAP THE MOUNT OF THE MOUNT OF HORIZON TO A LEST WAS THE MOUNT OF THE MOUNT OF HORIZON TO THE MOUNT OF THE MO

UNDERDRAINS SHALL BE PLACED AS SHOWN ON THE SITE DRAWINGS, UNDERDRAINS SHALL BE INSTALLED TO POSITIVELY DRAIN TO A SUITABLE DISCHARGE POINT AWAY FROM THE STRUCTURE. REFER TO SITE DRAWINGS FOR ADDITIONAL INFORMATION.

EXTERIOR CONCRETE SLABS ON GRADE SHALL BE UNDERLAIN BY AT LEAST 6'40' OF CRUSHED STONE, UNLESS OTHERWISE NOTED, REINFORCE SLABS WITH #4 @ 12' EACH WAY AT CENTER OF SLAB.

12 FOUNDATION WALL REINFORCING WILL BE ADJUSTED AS REQUIRED NOT TO INTERFERE WITH ANY BASE PLATE ANCHOR BOLTS

13. EXCAVATIONS FOR BUILDING FOUNDATIONS AND STRUCTURES SHALL BE IN ACCORDANCE WITH OSHA REQUIREMENTS. BRACED EXCAVATIONS SHALL BE DESIGNED BY A PROFESSIONAL BIOINIZER REGISTRED IN THE PROJECT STATE. DO NOT UNDERMINE SUSTINIS ADJACENT POUNDATIONS. REFER TO GESTERONIZE REPORT FOR ADDITIONAL MODION MORE SPECIAL.

14. IN NO CASE SHALL HEAVY EQUIPMENT BE PERMITTED CLOSER THAN 8-0" FROM ANY POUNDATIONBASEMENT WALL. IF THE CONTRACTOR DEBUS IT INCESSARY TO OPERATE SUCH EQUIPMENT CLOSER THAN 8-0". THE CONTRACTOR SHALL BE SOLELY RESPONSIBLE AND, AT HIS OWN EXPENSE PROVIDE ADEQUATE SUPPORTS OR WALL BRACES TO WITHSTAND THE ADDITIONAL LICHOS SUPPRINCIPACED FROM SICH EQUIPMENT.

STRUCTURAL STEEL NOTES:

STRUCTURAL STEEL FABRICATION
 ERECTION AND CONNECTION DESIGN SHALL CONFORM TO AISC 'SPECIFICATION FOR THE DESIGN
FABRICATION AND ERECTION OF STRUCTURAL STEEL' LATEST EDITION, AND THE 'CODE OF STANDARD PRACTICE' LATEST EDITION.

STRUCTURAL STEEL PLATES, SHAPES AND BARS, CONFORM TO ASTM ASS UNLESS NOTED OTHERWISE (U.M.O.), STRUCTURAL STEEL SHAPES DESIGNATED ON THE DRAWNISS FOR WISE FAMOS SECTIONS ASTM ASSZ (ASTM ASTZ GRADE SO WITH SPECIAL REQUIRED

STRUCTURAL TUBING: CONFORM TO ASTM A500 GRADE B 46 KSI.

CONNECTION DESIGN FOR THE PROJECT IS THE RESPONSIBILITY OF THE FABRICATOR, CONNECTION CALCULATIONS, SIGNED AND SEALED BY A PROFESSIONAL BIGHIESE LICENSED IN THE PROJECT STATE SHALL BE SUBMITTED WITH THE SHOP DRAWNINGS FOR THIS PROJECT, SEE THE PROJECT SEPCIOLATIONS FOR ACIDITIONAL RESURRENCES.

FJELD CONNECTIONS SHEEL BE BOLTED USING ASTM A325N HIGH STRENGTH BOLTS (U,N,O,) EXCEPT WHERE SLIP-CRITICAL
CONNECTIONS ARE REQUIRED AND NOTED BY A325 (SC) ON THE DRAWINGS. USE A490 BOLTS WHERE INDICATED.

WHERE WELDING IS INDICATED, ALL WELDING SHALL CONFORM TO AWS D1, H-ATEST EDITION, ELECTRODES SHALL CONFORM TO AWS A5.1 ETOXX SERIES WITH PROPER ROD TO PRODUCE OPTIMUM WELD (LOW HYDROGEIN.

7 SEE CONCRETE NOTES AND DRAWINGS FOR ANCHOR BOLT INFORMATION TVP

PROVIDE ¼" THICK LEVELING PLATE UNDER ALL COLUMN BASE PLATES UNLESS OTHERWISE NOTED. LEVELING PLATES SHALL BE SET AND GROUTED PRIOR TO ERECTING COLUMNS.

PROVIDE ALL MISCELLANEOUS ANGLES, PLATES, ANCHORS, ETC. SHOWN ON ARCHITECTURAL DRAWNINGS FOR SUPPORT OF BLOCKINGS-PARAPETS, FINSHES, ETC. COORDINATE WITH MISCELLANEOUS METAL FABRICATOR TO ENSURE COMPLETE COVERAGE OF ALL ITEMS.

CONCRETE WORK SHALL COMPLY WITH ACI 301 SPECIFICATIONS FOR STRUCTURAL CONCRETE BUILDINGS. ACI 316 BUILDING CODE REQUIREMENTS FOR REINFORCED CONCRETE. ACI 315 ACI DETAIL MANUAL., AND CRSI "MANUAL OF STANDARD PRACTICE."

2 CONTRACTOR SHALL PROVIDE TIES AND BRACING WHERE NECESSARY DURING CONSTRUCTION, TO REMAIN IN PLACE UNTIL THE STRUCTURES ARE COMPLETE.

CONCRETE SHALL BE:
A. FOOTING AND FOUNDATION WALLS 3500 PSIAT (28) DAYS (NIC = 0.49) ARE INTRANED,
B. INTERNOR AABSCH-GRADE. 4,000 PSI CONCRETE AT (20) DAYS. SLUMP SHALL NOT EXCEED 4 NICHES ** SINCH (NIC =

0.52), NO AIR.

EXTERIOR SLABS ON GRADE SIDEWALKS, AND STAIRS SHALL BE 4000 PSI AT (28) DAYS, SLUMP SHALL NOT EXCEED 4-INCHES +- 1-INCH (WIC = 0,45), AIR-ENTRAINED, SEE SPECIFICATIONS SECTION 03 30 00 FOR FURTHER CAST-IN-PLACE CONCRETE REQUIREMENTS,

COLICRETE SURFACES.

LICHTWEIGHT AGGREGATES ASTIM G330.
WATER POTABLE.

MATER POTABLE.

AR-ENTEANING ADMITURE. ASTIM G30.
HIGH-RANGE WATER REDUCING ADMITURES (SUPER PLASTICIZER) ASTIM C494 TYPE F OR G CONTAINING NOT MORE
THAN 15, CH. GRODE IONS.
HORMAL RANGE WATER REDUCING ADMITURES ASTIM C494 TYPE A CONTAINING NO CALCIUM CHLORIDE.
ACCELERATING ADMITURITIES ASTIM C494. TYPE C OR E.

ACCELERATING ADMITURITIES ASTIM C494. TYPE C OR E.

PROVIDE PVC SLEEVES WHERE PIPES PASS THROUGH CONCRETE WALLS OR SLABS,

CONCRETE SHALL NOT BE PLACED ON FROZEN GROUND OR IN WATER

REINFORCING BARS SHALL CONFORM TO ASTM A615 GRADE 60 DEFORMED BARS, AND SHALL BE DETAILED, FABRICATED AND ERECTED IN ACCORDANCE WITH ACI 315-LATEST EDITION,

COMPLETE SHOP DRAWINGS AND SCHEDULES OF ALL PENFORCING STEEL SHALL BE PREAPRED BY THE CONTRACTOR AND SUBMITTED TO THE ENGINEER FOR REVIEW PRICK TO COMMENCEMENT OF THAT PORTION OF THE WORK. ALL ACCESSORIES MUST BE SHOWN ON THE SHOP DRAWINGS.

UNLESS OTHERWISE NOTED, 4-INCH SLABS ON GRADE SHALL BE REINFORCED WITH 6 X 6 X W2.9 X W2.9 X W2.9 WELDED WIRE FABRIC, WELDED WIRE FABRIC SHALL BE PROVIDED IN FLAT SHEETS AND CONFORM TO ASTM A-185.

UNLESS OTHERWISE NOTED, SPACINGS OF CONSTRUCTION JOINTS IN FOOTINGS AND WALLS SHALL NOT EXCEED 44-0°, OR 19-0°
FROM ANY CONNER. THESE MANUMUS CAN BE EXCEEDED OUR Y INVESTED INTERMEDIATE CONTRACTION JOINTS ARE PROVIDED.
MINIMUM OF THORIS SHALL BAPES SERVICES INJUSCIT CONCERTS FLOORCHISTS.

REINFORCEMENT SHALL BE CONTINUOUS AROUND CORNERS AND AT INTERSECTIONS, PROVIDE LAPPED BARS AT NECESSARY SPLICES OR HOOKED BARS AT DISCONTINUOUS BIOS. PROVIDE TENSION LAP SPLICES FOR ALL REINFORCING UNLESS OTHERWISE SHOWN ON PLAN.

12. ALL CONSTRUCTION JOINTS FOR SLABS SHALL BE KEY JOINTED AT MID-SPAN WITH REINFORCING DISCONTINUOUS AT JOINT.

FLOOR SLAB-ON-GRADE CONTROL JOINTS SHALL BE PLACED AS SHOWN ON THE FOUNDATION PLAN, UNLESS OTHERWISE NOTED, CONTROL JOINTS WILL BE SPACED NOT TO EXCEED 12-0" ON-CENTER IN BOTH DIRECTIONS AND SHALL BE FILLED WITH SEALANT AT THE COMPLETION OF THE PROLECT.

14. CONTRACTOR SHALL CHECK WITH EACH TRADE TO ASSURE CORRECT LOCATION, SIZE, LINE AND ELEVATION OF SLEEVES, BOND-OUTS, ETC. REQUIRED IN CONCRETE FLOORS AND WALLS.

15. THE CONTRACTOR SHALL BE RESPONSIBLE FOR FLOOR DRAIN SETTING AND EXTENTS OF AREA SLOPE TO DRAIN DEVELOPMENT, SEE ARCHITECTURAL AND PLUMBING PLAINS TO ENSURE COMPLETE AREA DRAINAGE.

17. EXPOSED CONCRETE SHALL BE NEATLY FINISH-RUBBED.

MECHANICAL EQUIPMENT RESTING ON THE CONCRETE FLOOR SLAB SHALL HAVE A 4-INCH HIGH CONCRETE PAD UNDERNEATH, EXTENDING A MINIMUM OF ANICHES BEYOND UNIT EDGE (EACH DIRECTION), REINFORCED WITH #3 BARS AT 16-INCHES OIL-CENTER EACH WAY.

19. STRUCTURAL STEEL BELOW FINISH FLOOR SHALL RECEIVE (2) COATS OF BITUMINOUS MASTIC.

 ADMIXTURES CONTAINING CALCIUM CHLORIDE SHALL NOT BE USED, CONCRETE SHALL NOT BE IN DIRECT CONTACT WITH ALUMINUM. 21. PROVIDE IN SLABS ON GRADE (2) BARS 4"-0" LONG AT EACH REENTRANT CORNER AND BOTH SIDES OF DOOR OPENING,

22. REFER TO ACI 318 -LATEST EDITION FOR MINIMUM CONCRETE COVER FOR REINFORCING STEEL.

23. UNLESS OTHERWISE NOTED, REINFORCING LAP SPLICES SHALL BE ACI CLASS B SPLICES USING THE FOLLOWING LAP LENGTHS.

BAR SIZE: 3 4 5 6 7 8 LAP (IN): 30 36 48 56 81 93

24. COORDINATE SLAB DEPRESSIONS AND ALL INTERIOR FLOOR SLOPES TO DRAIN LOCATIONS WITH ARCHITECTURAL AND PLUMBING DRAWINGS.

SLAB THOMIESSES (ELEVATED OR ON-GRADE) INDICATED ON THE DRAWINGS ARE MINIMUMS, PROVIDE SUFFICIENT CONCRETE TO ACCOUNT FOR STRUCTURE DEFLECTION AMONE SUBBRADE FLUCTUATIONS IN ORDER TO OBTAIN SPECIFIED SLAB ELEVATIONS AT THE FLAT MESS AND LICENLESS INDICATED IN THE SPECIAL ORDITION.

26, ANCHOR BOLTS SHALL CONFORM TO ASTM F1554, GRADE 36 HOT-DIPPED GALVANIZED UNLESS NOTED OTHERWISE ON PLAN,

27. DRILLEDIN AUCHOR BOLTS OR REBAR DOVIELS SHALL BE INSTALLED AS FOLLOWS:
A. LOCATE ANCHOR BOLTS OR DOWES. STO AVIDI OUTTING EISTING RESAR.
B. DEFTH'S BASED ON A CIDEN HOLE WITH ADMIST SIES, TOTATY PREFOCUSION EQUIPMENT AND COURSE ROCK CUTTING CHESES, AND ESSES PROCEDURES RECOMMENDED. DIAMOND CORE BITS SHOULD BE AVIDED AS EMBEDMENT LENGTHS MAY NEED TO BE INCRESSED, NICE SEZ TO BE PER MANAFACTURES RECOMMENDATIONS.
C. CLEAN HOLES WITH COURSESSED AR OR VACUUM. REBINGE MAY FREESTANDING WATER AND ALLOW HOLE TO DRY, D. GROWN ANKHOR BOLTS OR OWNESS WITH HILT HIT HAVE ADMISTED AND ADMISTRATIVE PROFITER RECOMMENDATIONS, (HLTI HIM ADMESNIC CAPSULE MAY BE SUBSTITUTED FOR THE HLTI HT HY 100 ADMESNICE.)

PROVIDE AND INSTALL MASONRY LINTELS FOR MASONRY WALL OPENINGS UNLESS INDICATED OTHERWISE ON DRAWINGS. PROVIDE MASONRY LINTELS OF SIZE AND REINFORCEMENT AS FOLLOWS:

A. OPENINGS UP TO 3-11" (UNLESS NOTED OTHERWISE): PROVIDE 8-INCH HIGH CALLUL, INTEL W(2) & LINEAR LINEA

- DATIG IN CHINCH WIDE UNITS.

OPENINGS 4"4" TO 8"4" (UNILESS OTHERWISE NOTED): PROVIDE 16 INCH HIGH C.M.U. LINTEL WV (2)
#6 BARS IN 8-INCH WIDE UNITS.

CONCRETE MASONRY LINTELS SHALL HAVE 8-INCH (MIN) END BEARING UNLESS OTHERWISE NOTED

CONCRETE MASONRY BLOCK WALLS WITH VERTICAL REINFORCING SHALL HAVE CORES FILLED WITH 3000 PSI GROUT, INSTALLATION OF REINFORCEMENT SHALL BE CONTINUOUS AND RUN UNOBSTRUCTED BY ANY BAR JOIST SEATIBEAM BEARING PLATE ARRANGEMENTS,

OMIT REBARIGROUTING IN MASONRY CELLS WHICH SHALL RECEIVE ROOF DRAIN LEADERS, CONDUITS, ETC. REQUIRED REINFORCEMENT SHALL BE INSTALLED IN THE ADJACENT CELL AND SHALL BE GROUTED SOLID.

HOLLOW CONCRETE BLOCK UNITS: ASTM C90 GRADE N TYPE 1 STANDARD WEIGHT BLOCKS INCLUDING STRETCHERS AND CORNER BLOCKS, MINIMUM PRISM STRENGTH OF BLOCK IN 28 DAYS SHALL BE, ℓ_n =

MORTAR: TYPE'S CONFORM TO ASTM-C476

GROUT: 3000 PSI MINIMUM 28 DAY COMPRESSIVE STREINGTH, CONFORM TO ASTIN C-478, ROD GROUT IMMEDIATELY AFTER POURING AND AGAIN APPROX, 5 MINUTES LATER, MAXINUM GROUT LIFT WITHOUT CLEANOUTS SHALL NOT EXCEED 4-07 IN BLOCK WALLS

REINFORCING FOR BOND BEAMS, LINTEL BLOCKS, AND VERTICAL WALL REINFORCING SHALL BE BILLET STEEL CONFORMINGT OF ANY MAST, GRADE 60, STANDARD LAY LENGTH OF GRADE 60 MASONINY BENDROCKING BARS SHALL BE 68 BRE DIAMETERS FOR BARS AND SHALLER, AND TSAN GOALINETERS FOR BARS AND BY, G.C. CITION TO PROVIDE MECHANICAL SPLICES RATED FOR 1298 THE BARY YIELD STREIGHT, APROVINCE CORRER BARS TO MATCH HORIZONTA REINFORCEMENT.

PLACE BOND BEAM REINFORCING CONTINUOUS THROUGH EXPANSION AND CONTROL JOINTS, WRAPPING BARS WITH 16 NICH THICK BOND BREAMING TARE 24 NICHES BOTH SIEDS OF JOINT, DO NOT SPLICE BOND BEAM REINFORCING WITHIN 6-210 OF AU EPANSION OR CONTROL JOINT,

PROVIDE CONTINUOUS WIRE LATHE GROUT BARRIERS AS REQUIRED UNDER FIRST COURSE OF GROUTED CELLS.

12. PROVIDE LADDER TYPE #9 HORIZONTAL JOINT REINFORCING AT 16-INCHES VERTICAL SPACING IN WALLS

WET MASONRY WALLS THOROUGHLY FOR (3) CONSECUTIVE DAYS IMMEDIATELY AFTER PLACEMENT IF TEMPERATURES AREWILL BE ABOVE 80°F DURING THE DAY.

14. MASONRY LAID IN OUTSIDE AIR TEMPERATURES BELOW 40°F SHALL BE PROTECTED IN ACCORDANCE WITH THE PROVISIONS OF THE "IMIAWC RECOMMENDED PRACTICES AND GUIDE SPECIFICATIONS FOR COLD WEATHER MASONRY".

15. MASONRY BLOCK CORES BELOW FINISH FLOOR SHALL BE FILLED SOLID WITH CONCRETE.

PROVIDE BOND BEAM WITH (2) #4 REBAR AT ALL TOP OF CMU WALL AND AT EACH FLOOR FRAMING LEVEL FIELD PENTERATIONS THROUGH BLOCK WALLS SHALL NOT BE MADE THROUGH BOND BEAMS, LINTELS OF GROUTED CELLS.

17, ALL MASONRY CONSTRUCTION SHALL CONFORM TO ACI 530,1 - LATEST,



COPYRIGHT CHA Architecture

Reuse or reproduction of the ontents of this document is no permitted without written ermission of CHA Architectur

04421 **ENOVATION** Maine

Castine, Academy, $\overline{\mathbf{C}}$ HALL Maritime ഗ RT

No. Date Description Revision Schedule

> NOT FOR CONSTRUCTION

JOB NO. 076982 ISSUE


100% CONSTRUCTION DOCUMENTS - ISSUED FOR BIDDING


TITLE STRUCTURAL -GENERAL INFORMATION


1/22/2023


SHEET


|S000

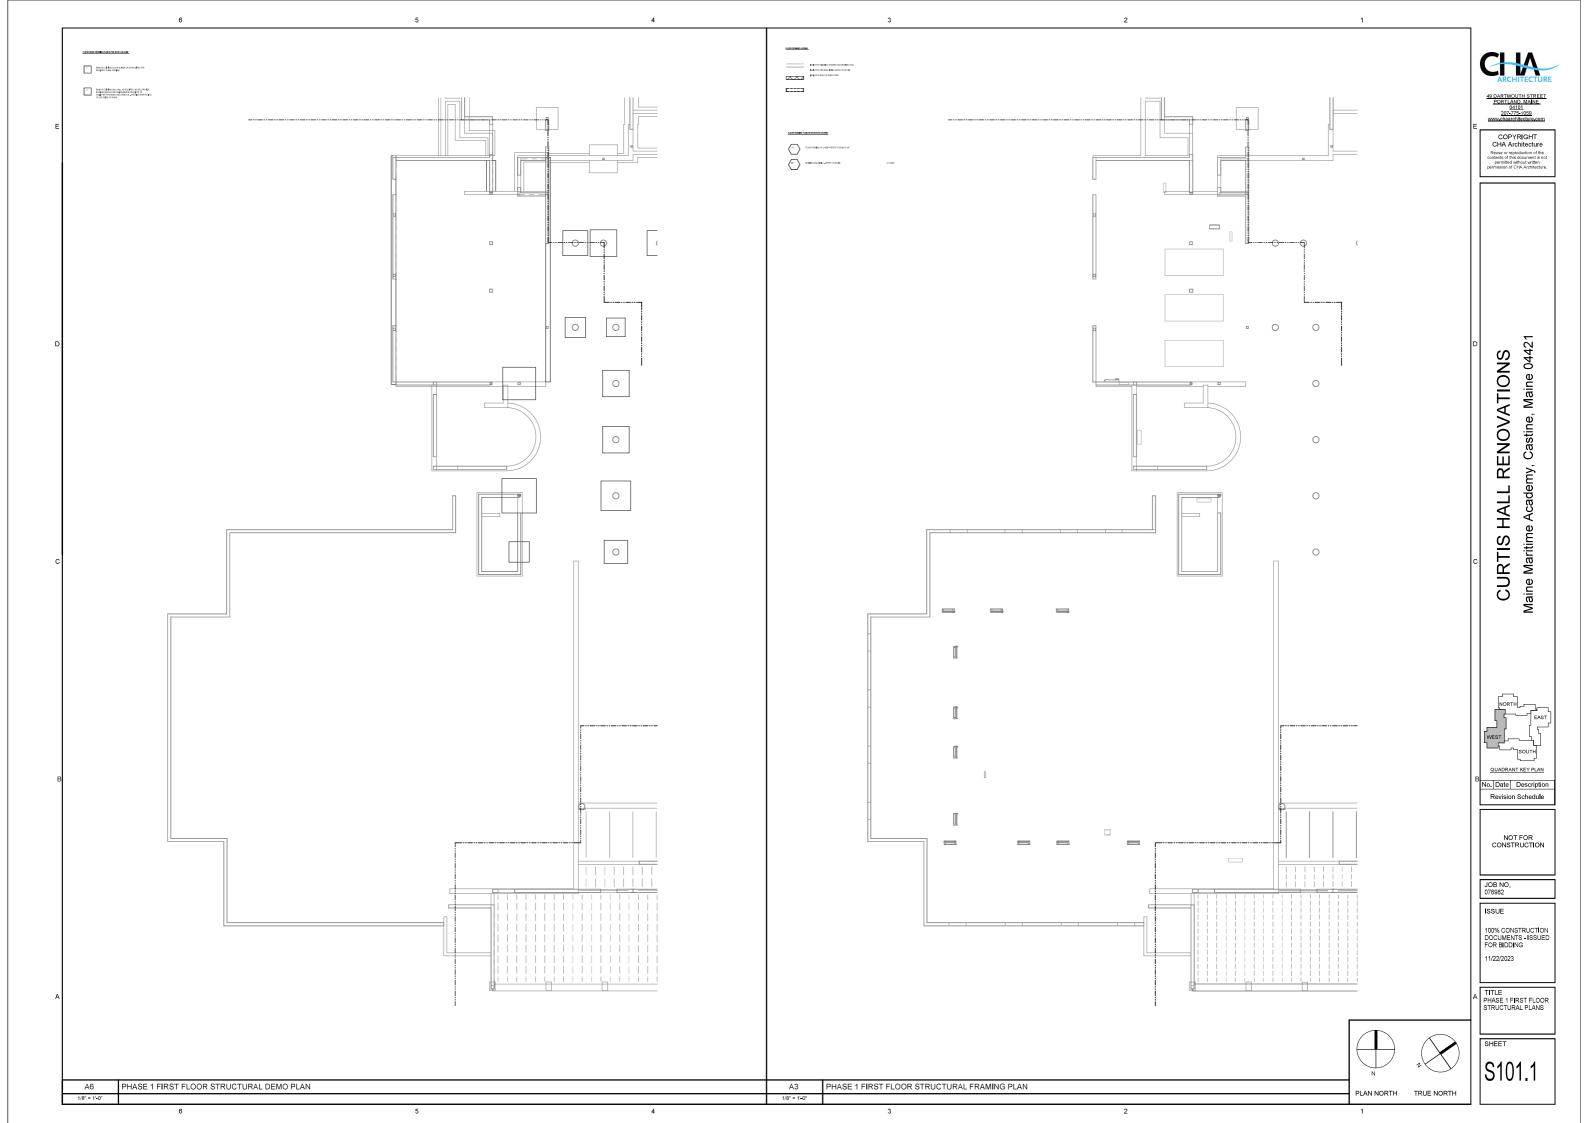

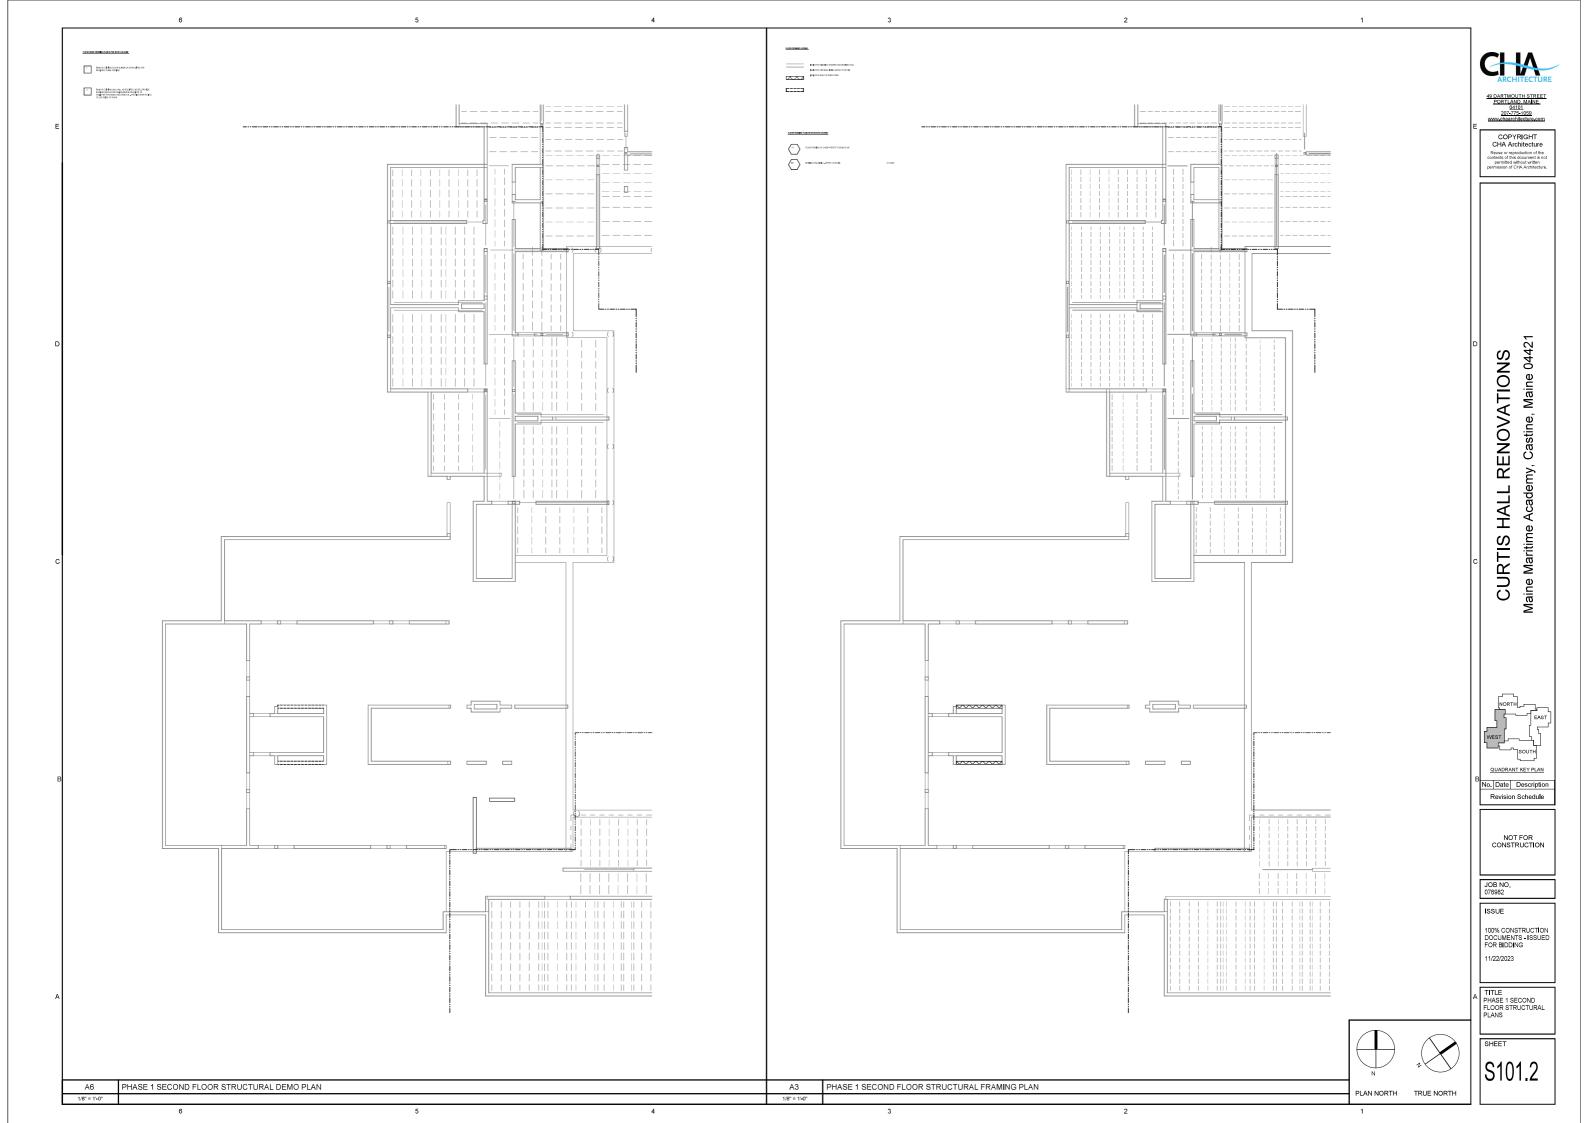


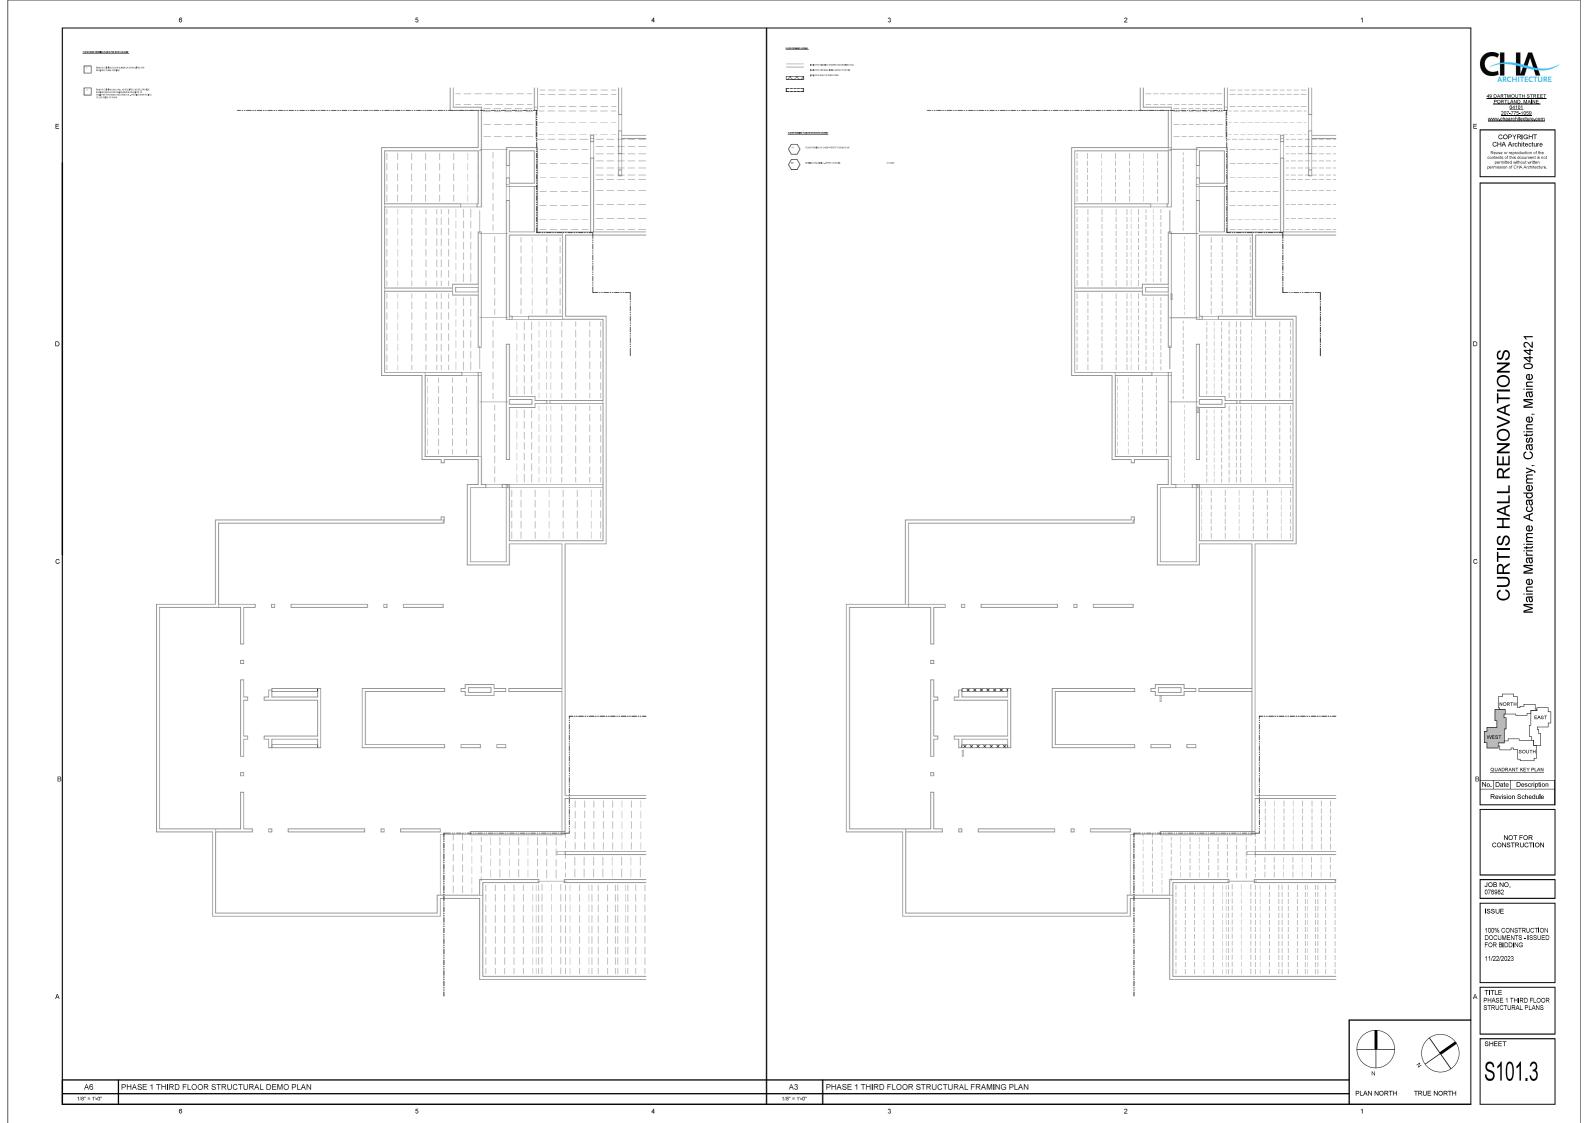

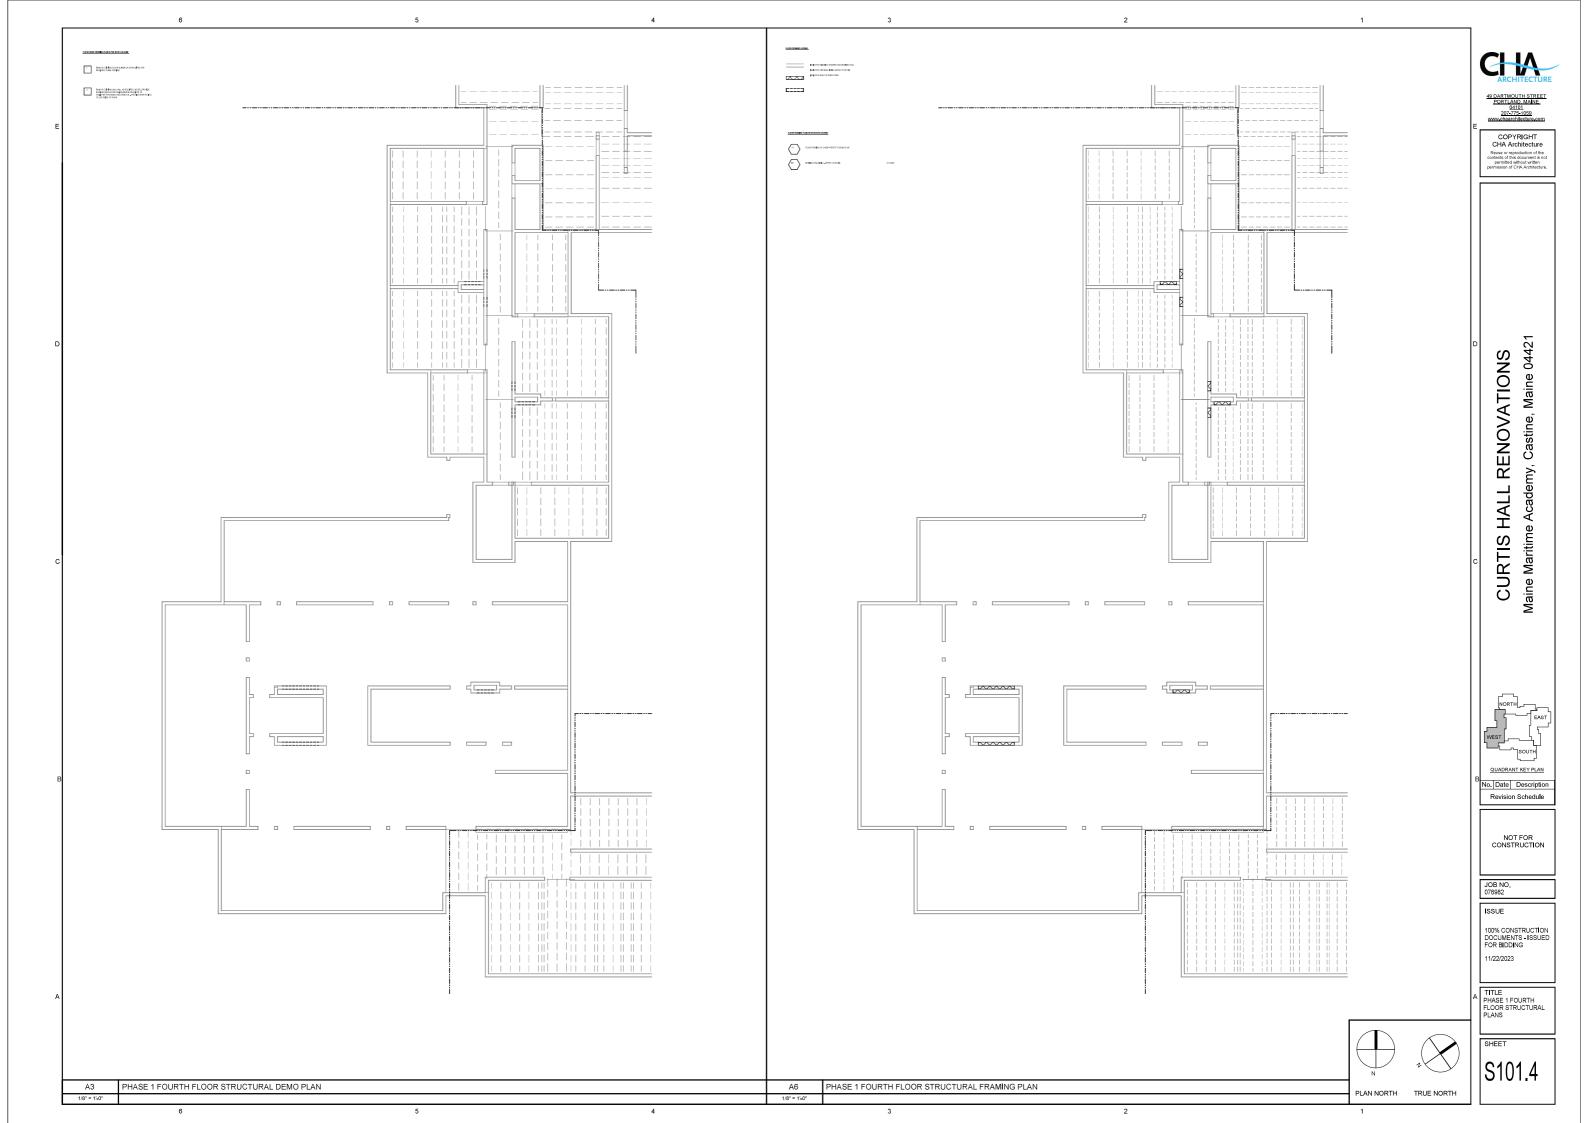

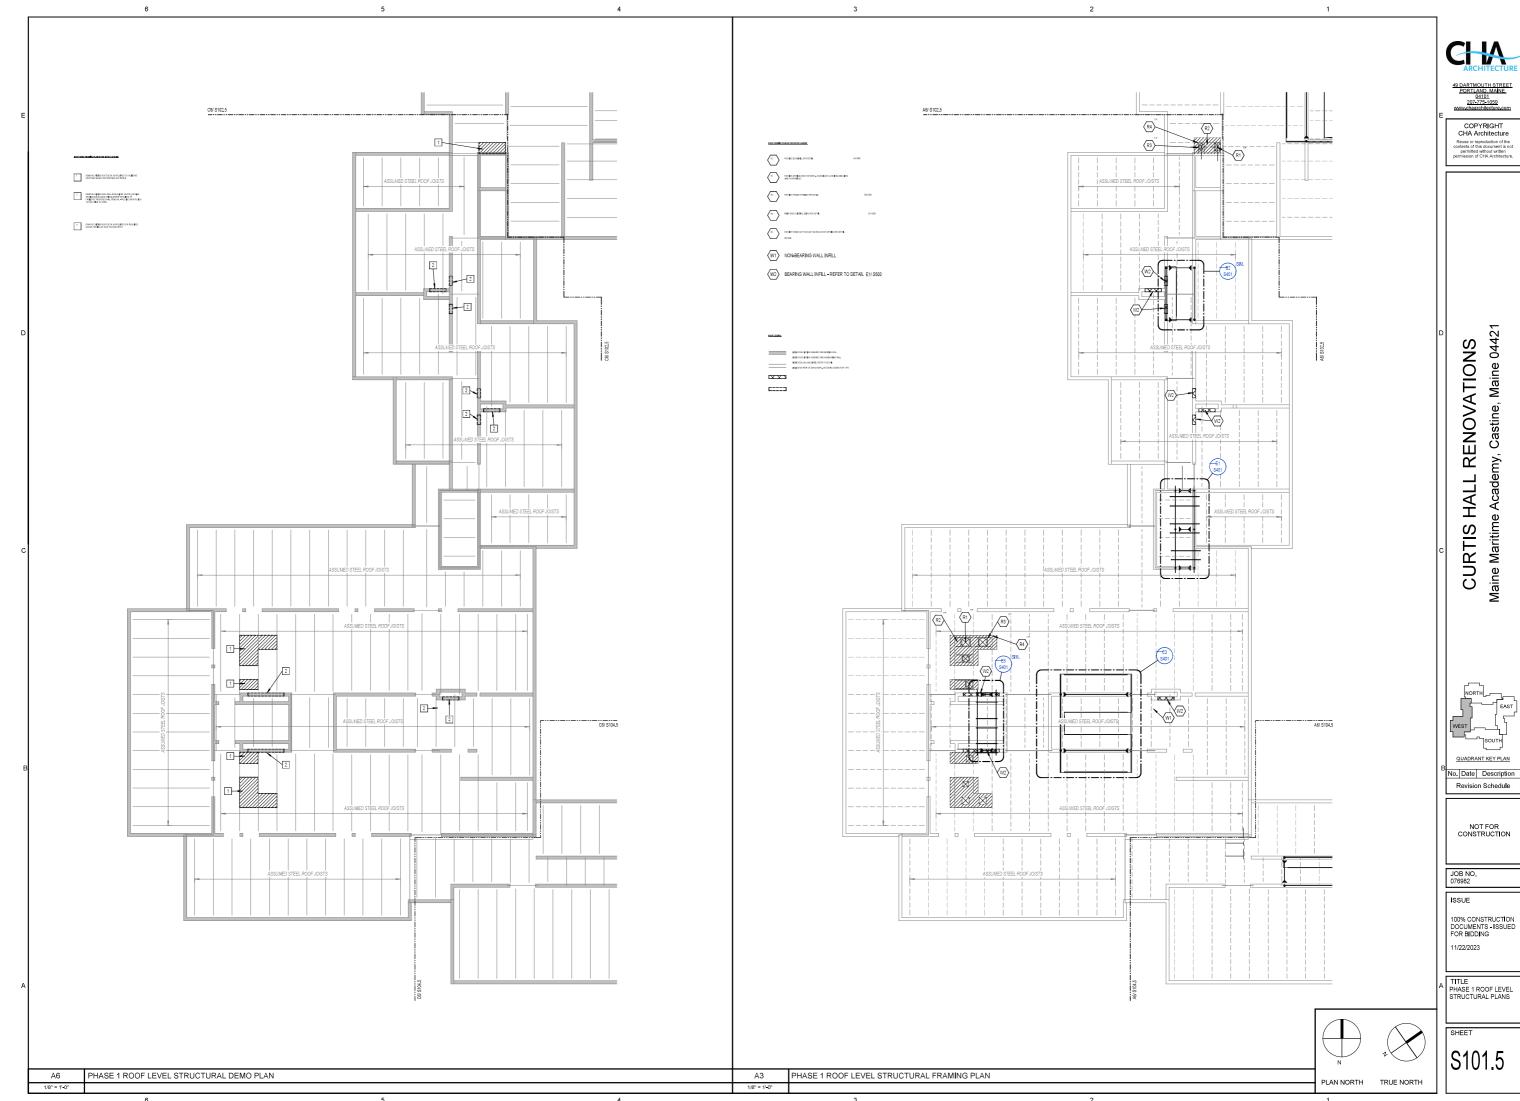



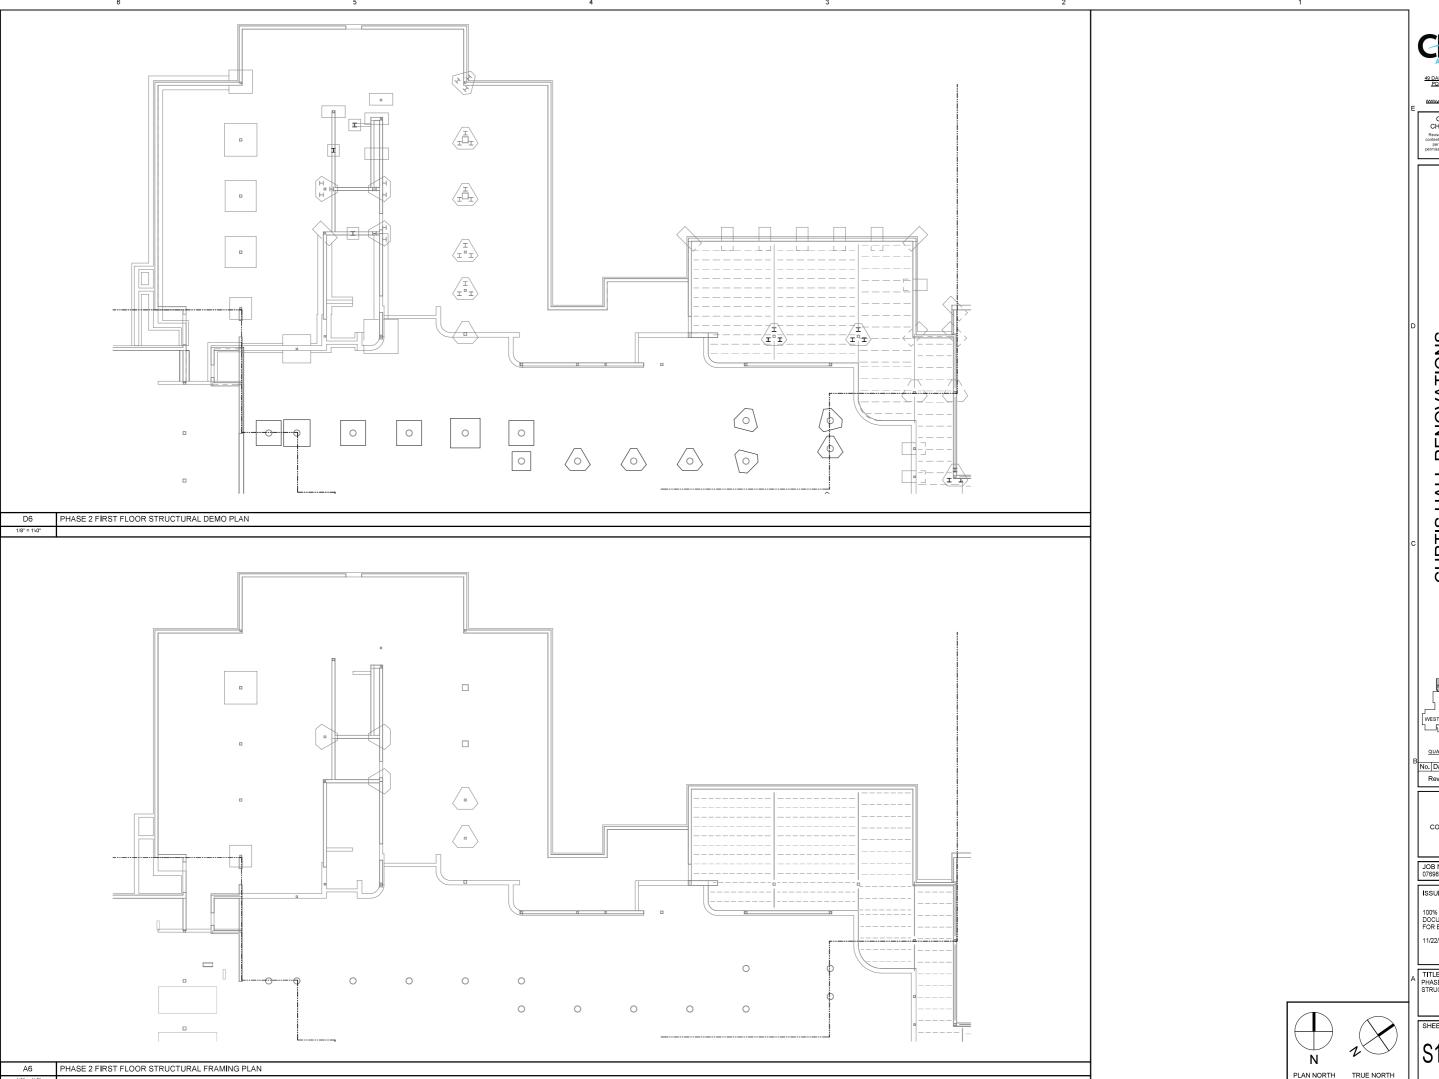

Maine Maritime Academy, Castine, Maine 04421


CURTIS HALL RENOVATIONS

Revision Schedule

NOT FOR CONSTRUCTION

100% CONSTRUCTION DOCUMENTS - ISSUED FOR BIDDING

TITLE
PHASE 2 FIRST FLOOR
STRUCTURAL PLANS

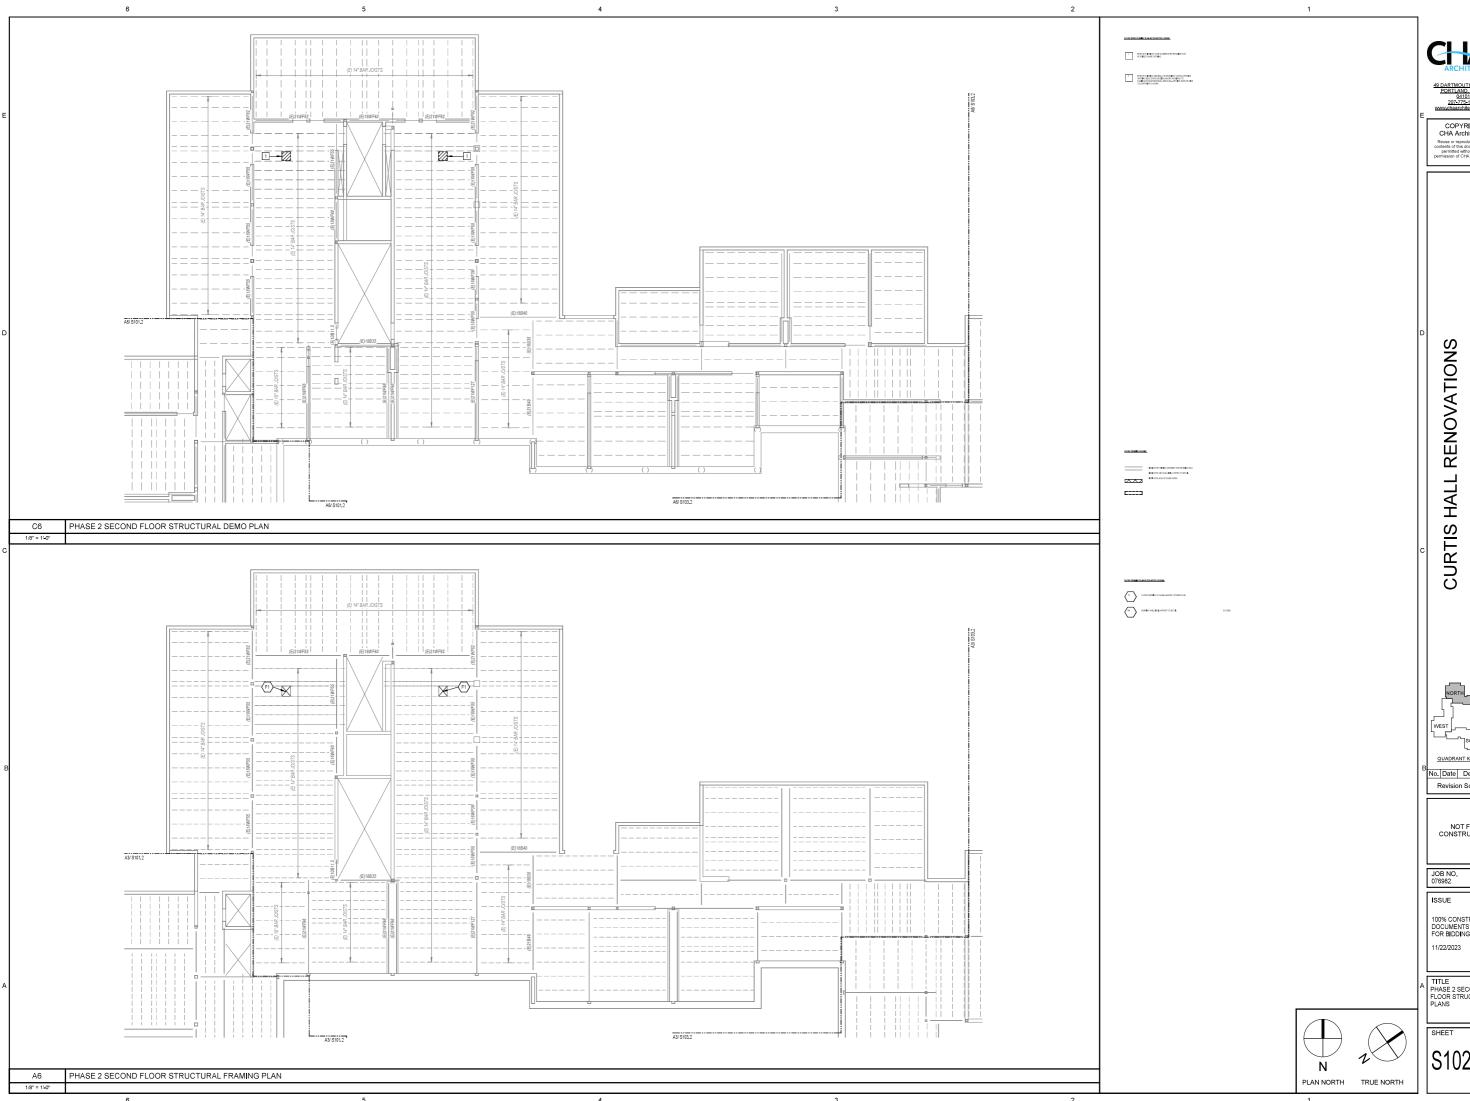


Maine Maritime Academy, Castine, Maine 04421

Revision Schedule

NOT FOR CONSTRUCTION

100% CONSTRUCTION DOCUMENTS - ISSUED FOR BIDDING

TITLE
PHASE 2 SECOND
FLOOR STRUCTURAL
PLANS

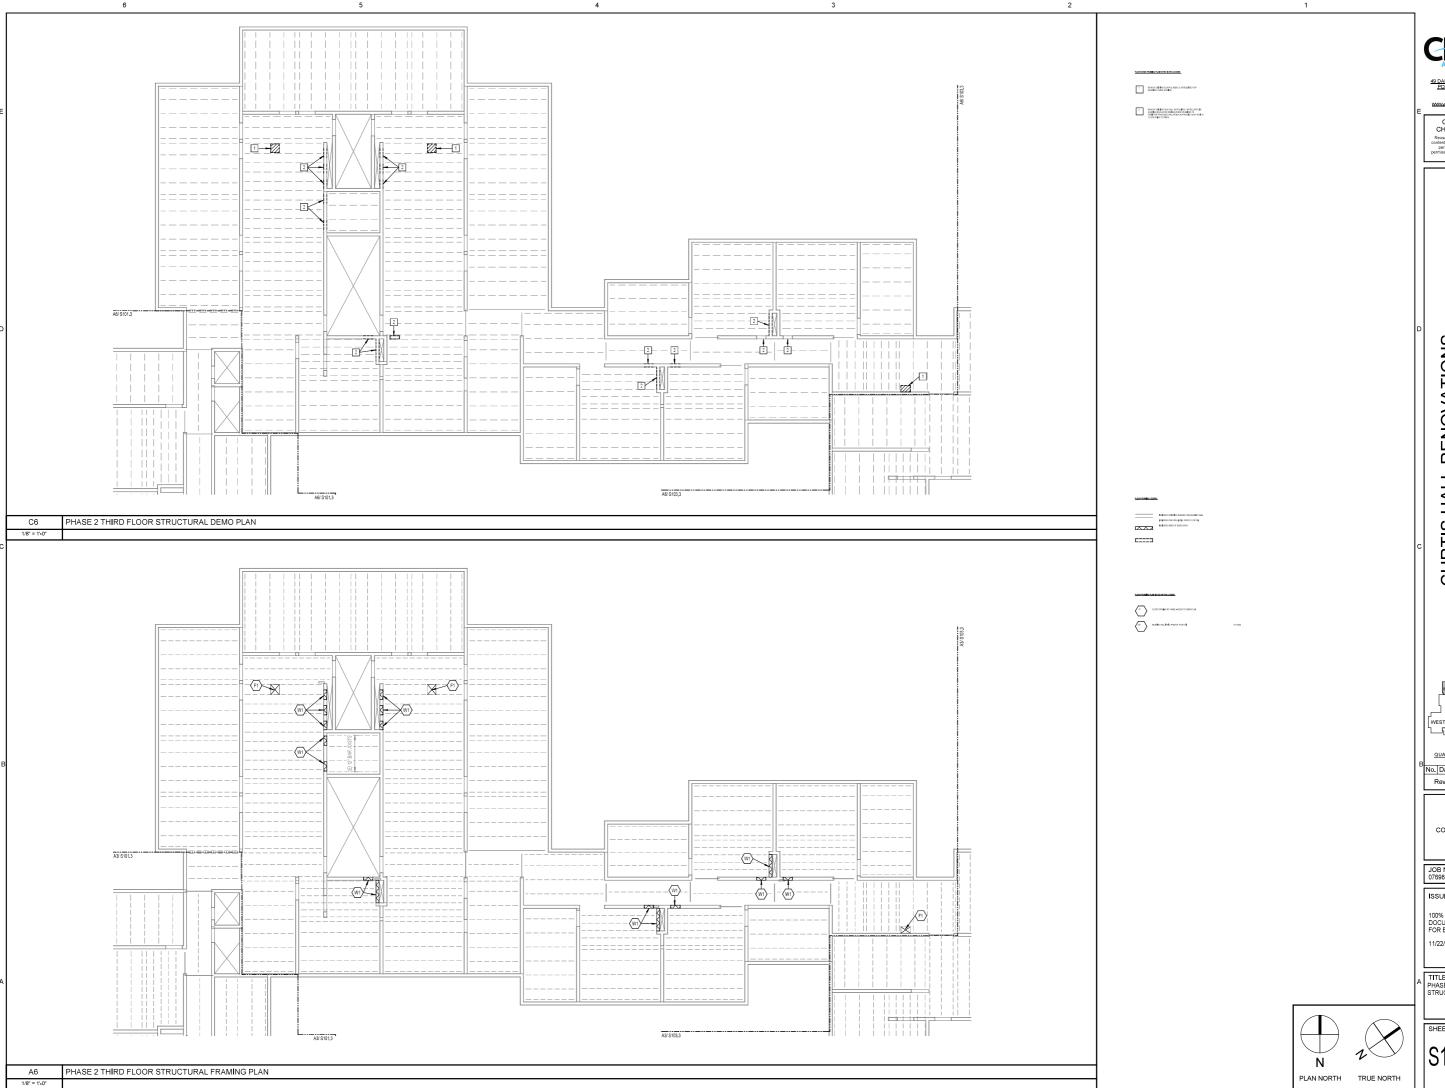


Maine Maritime Academy, Castine, Maine 04421 **CURTIS HALL RENOVATIONS**

NOT FOR CONSTRUCTION

100% CONSTRUCTION DOCUMENTS - ISSUED FOR BIDDING

TITLE
PHASE 2 THIRD FLOOR
STRUCTURAL PLANS

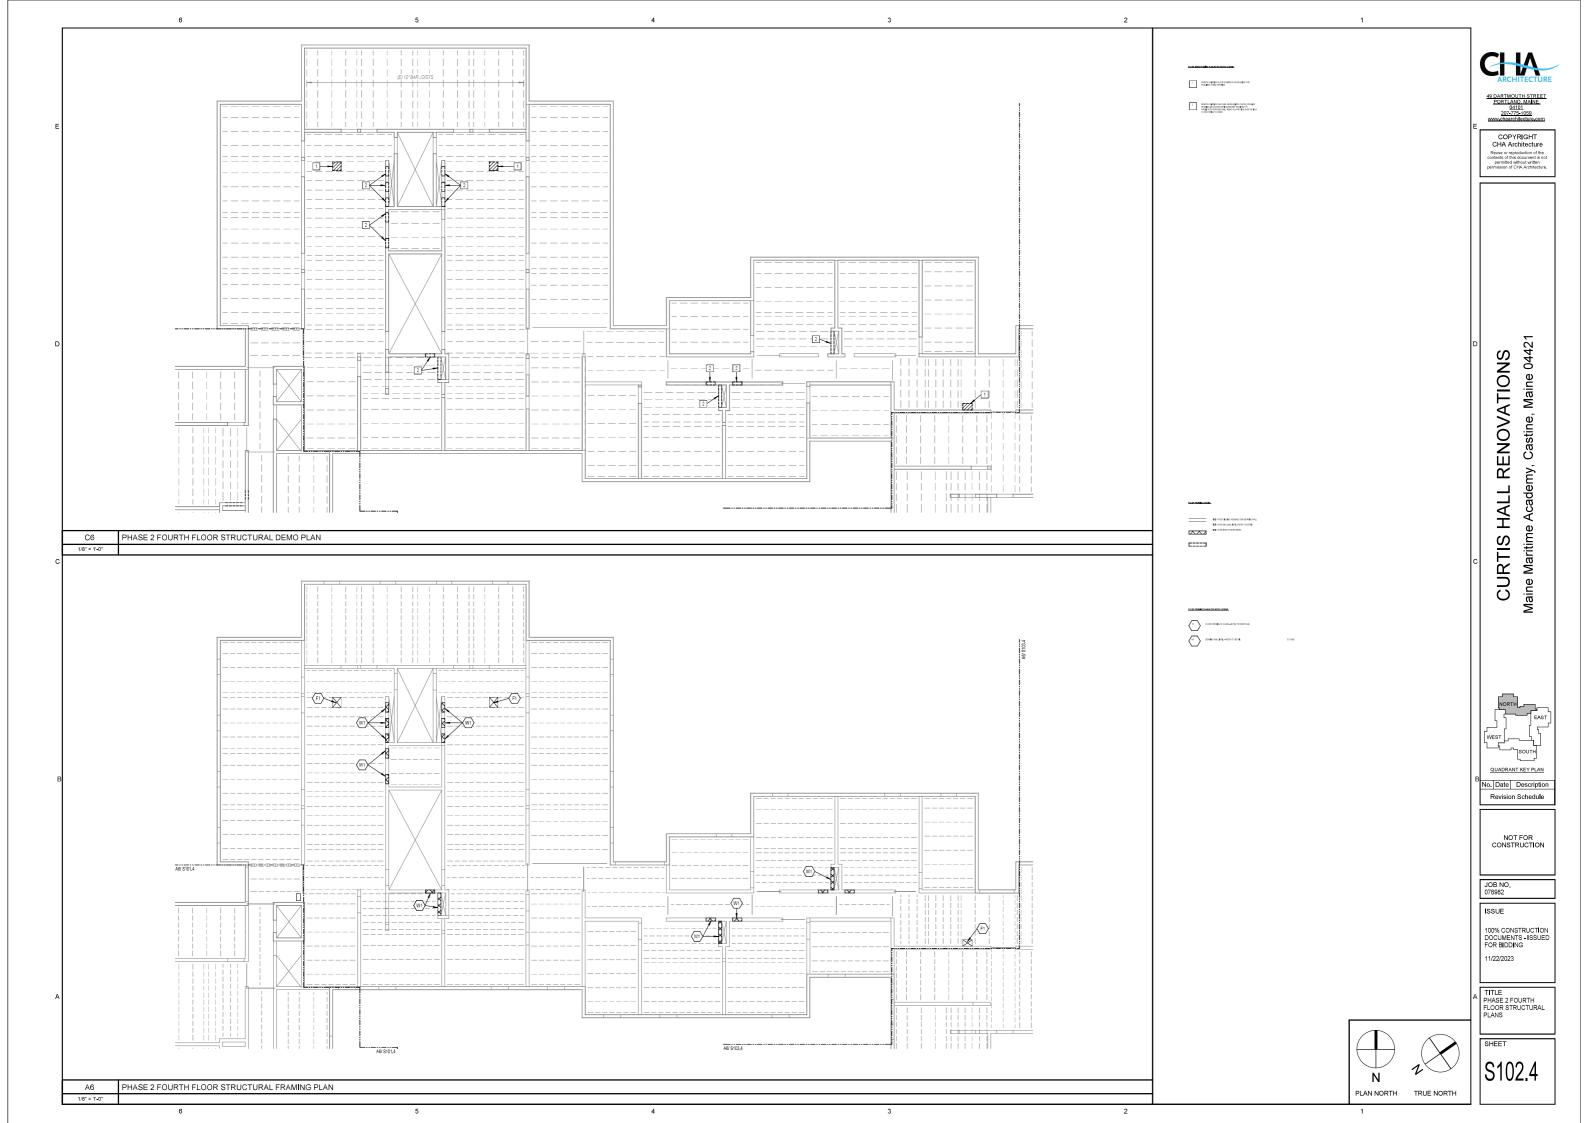




Maine Maritime Academy, Castine, Maine 04421 **CURTIS HALL RENOVATIONS**


Revision Schedule


NOT FOR CONSTRUCTION


100% CONSTRUCTION DOCUMENTS - ISSUED FOR BIDDING


TITLE
PHASE 2 ROOF LEVEL
STRUCTURAL PLANS

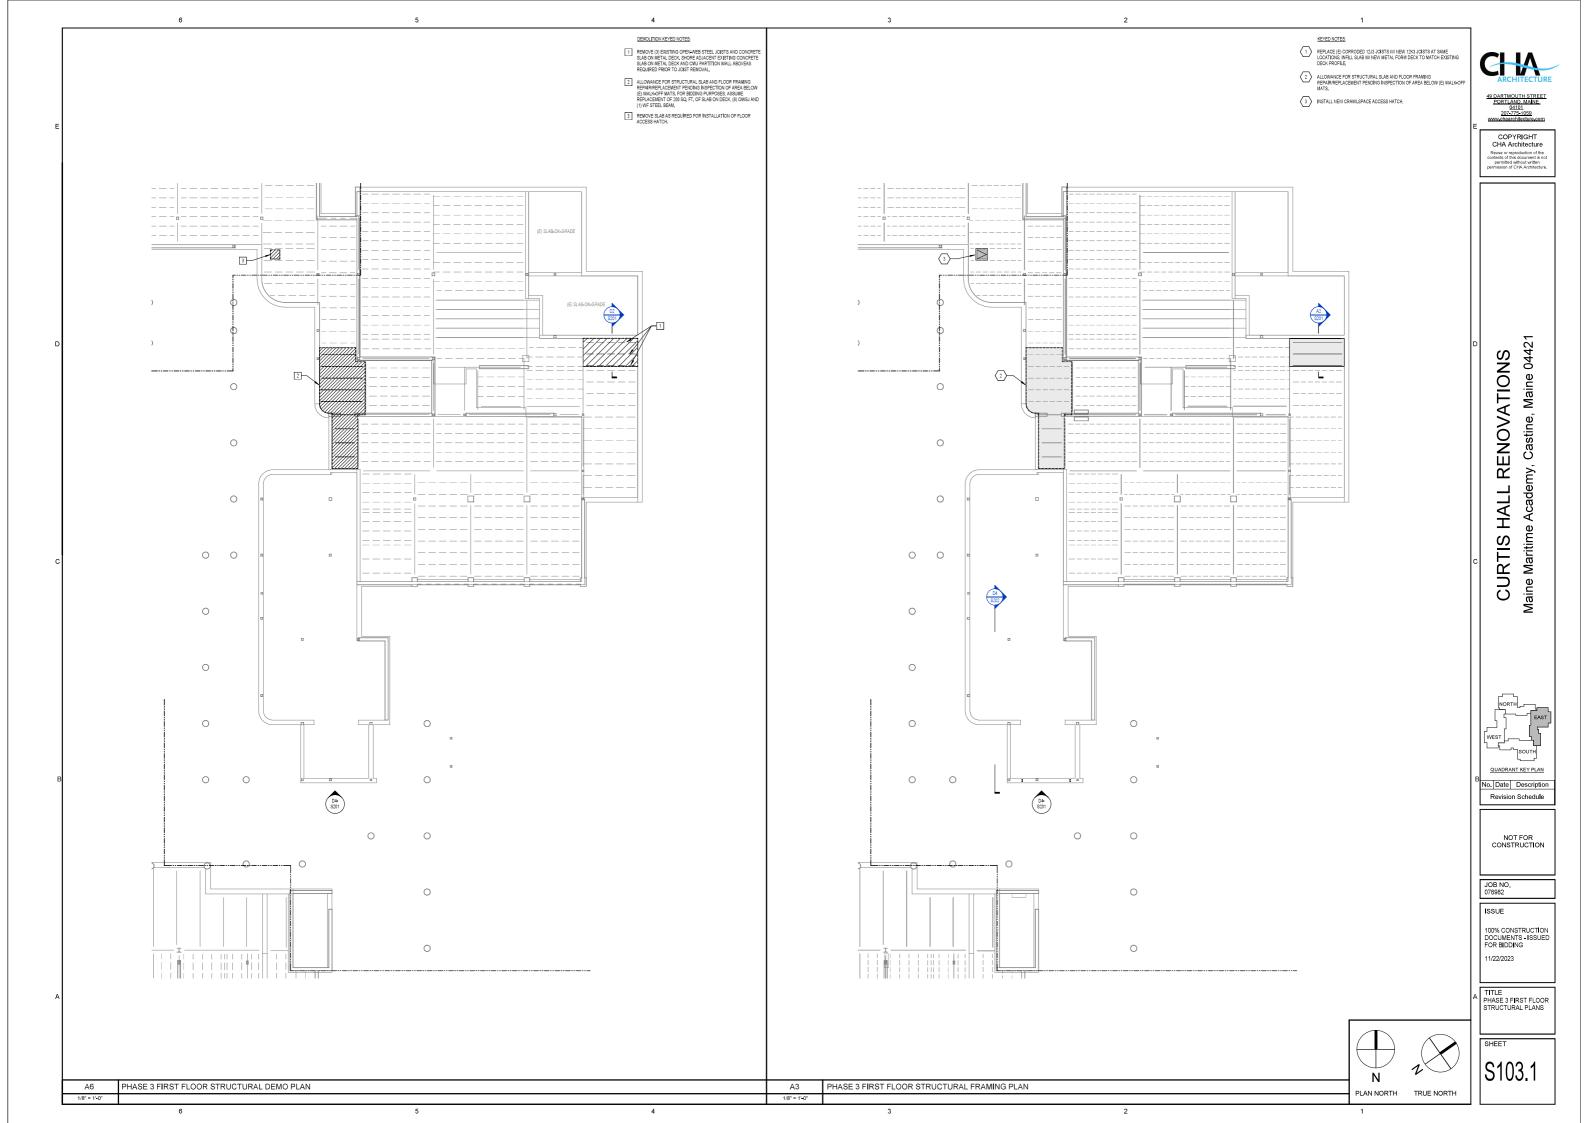

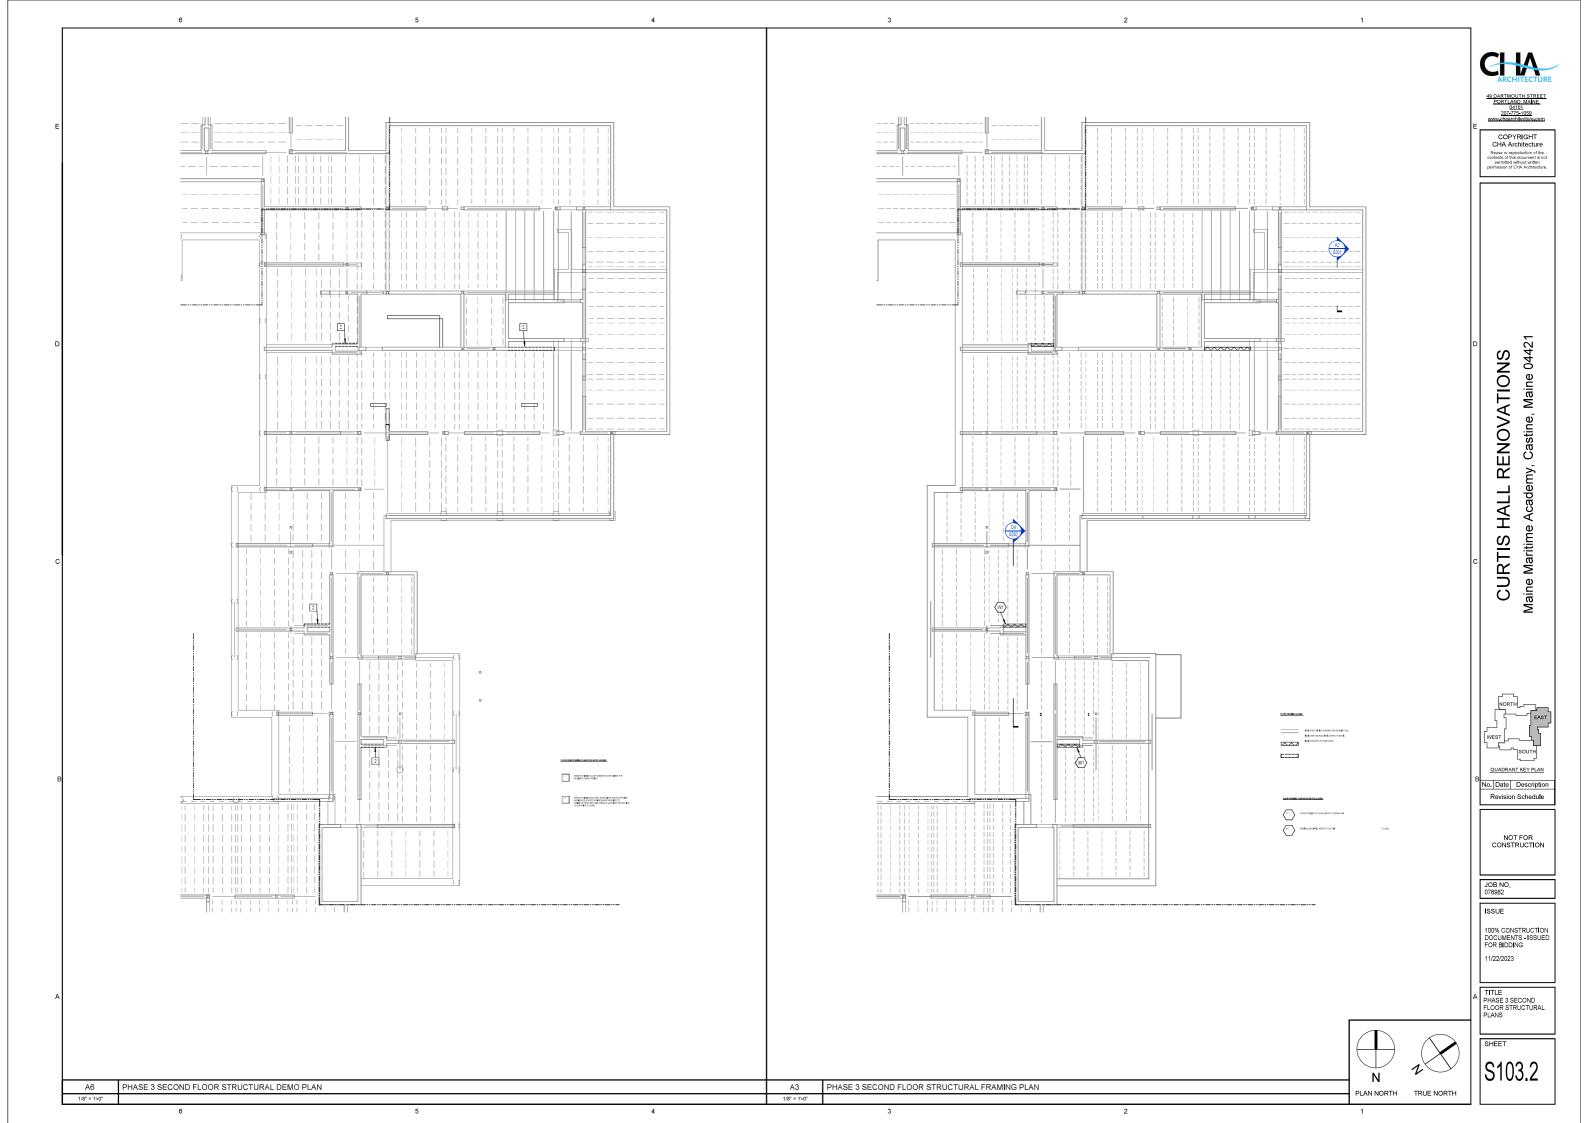

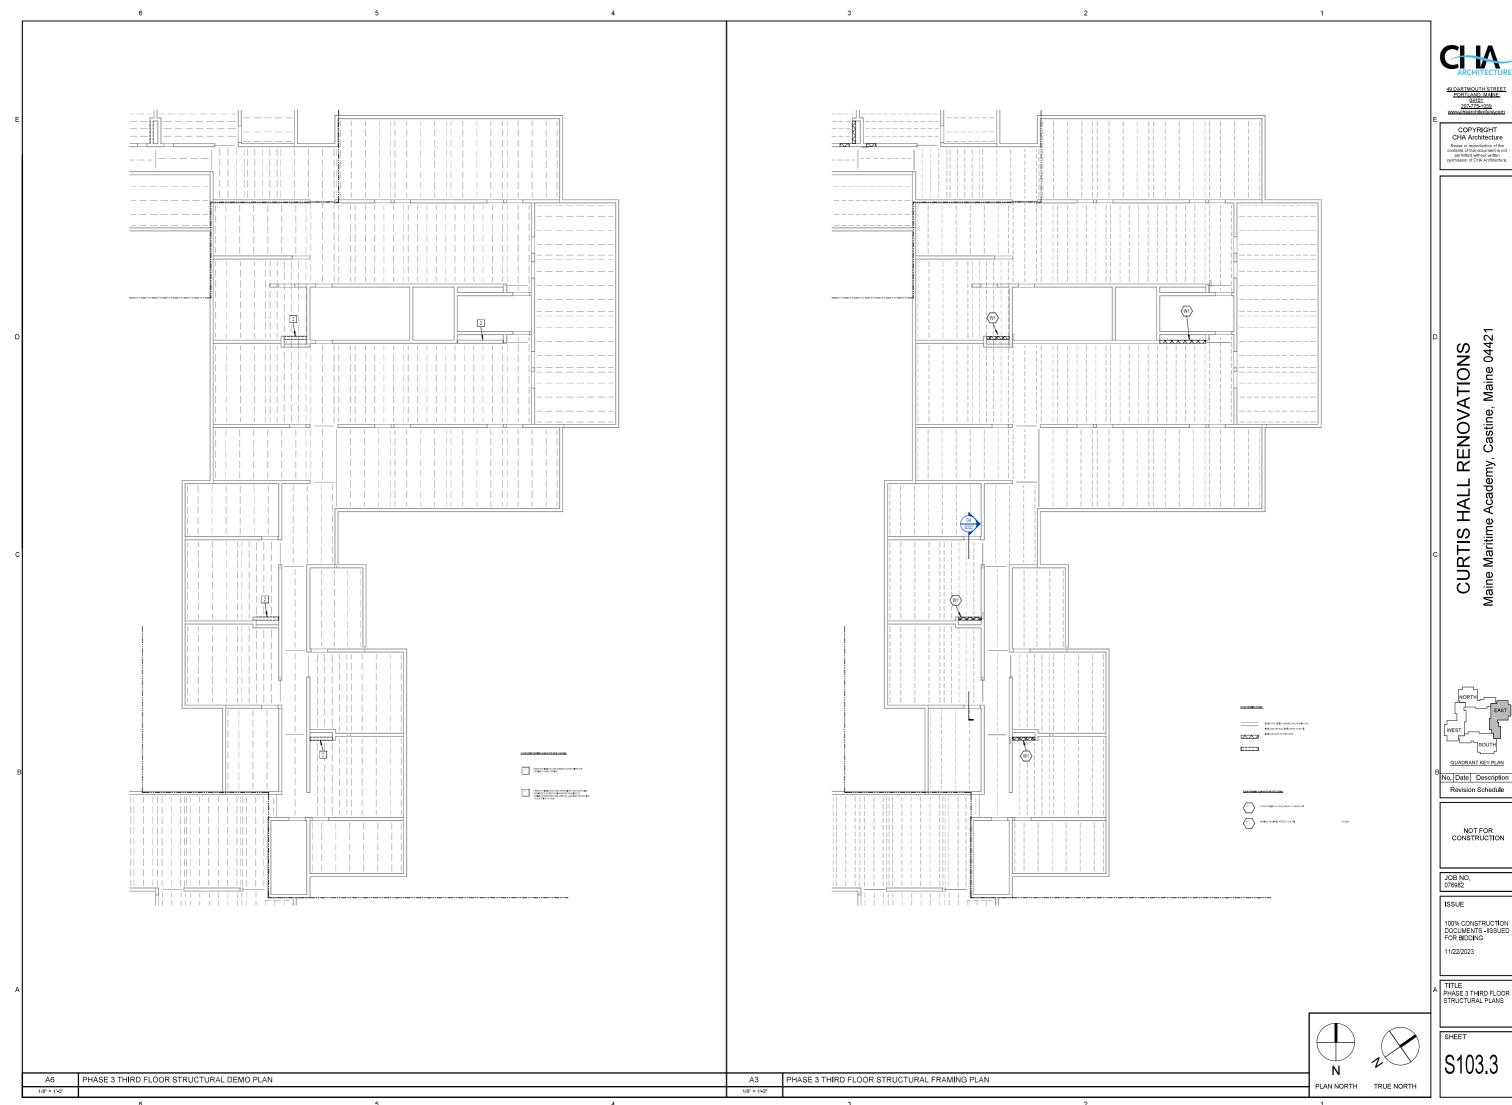

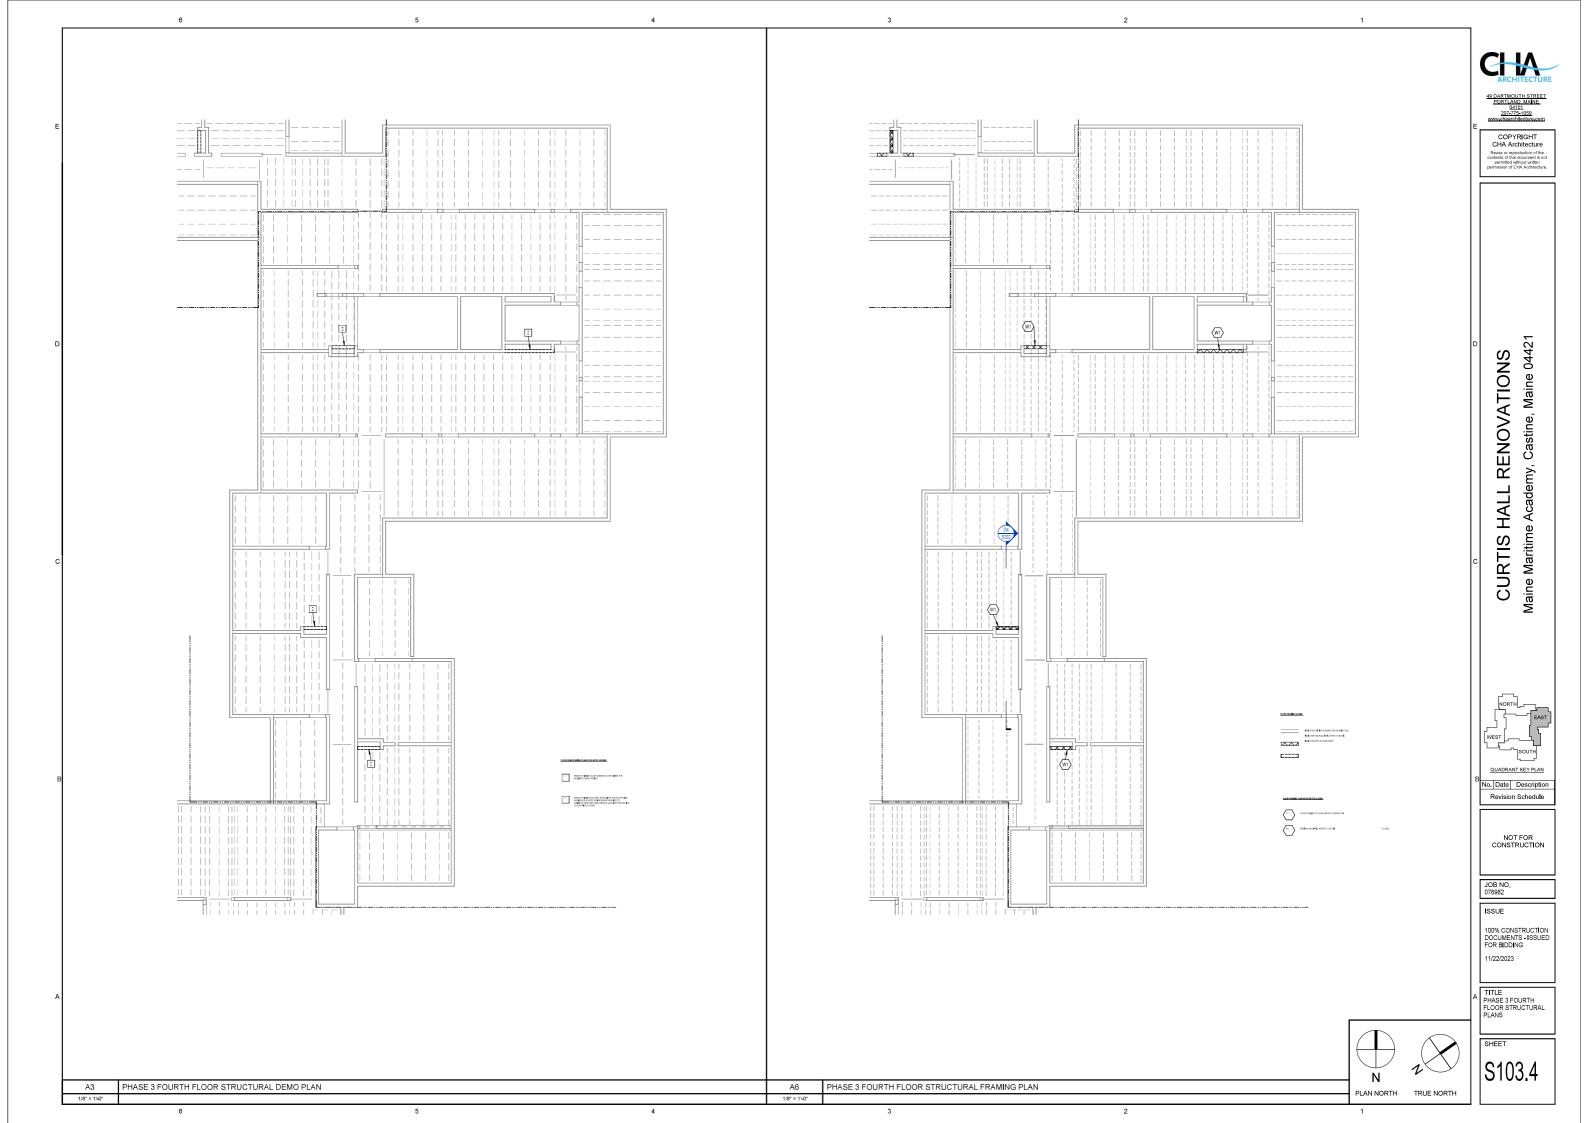


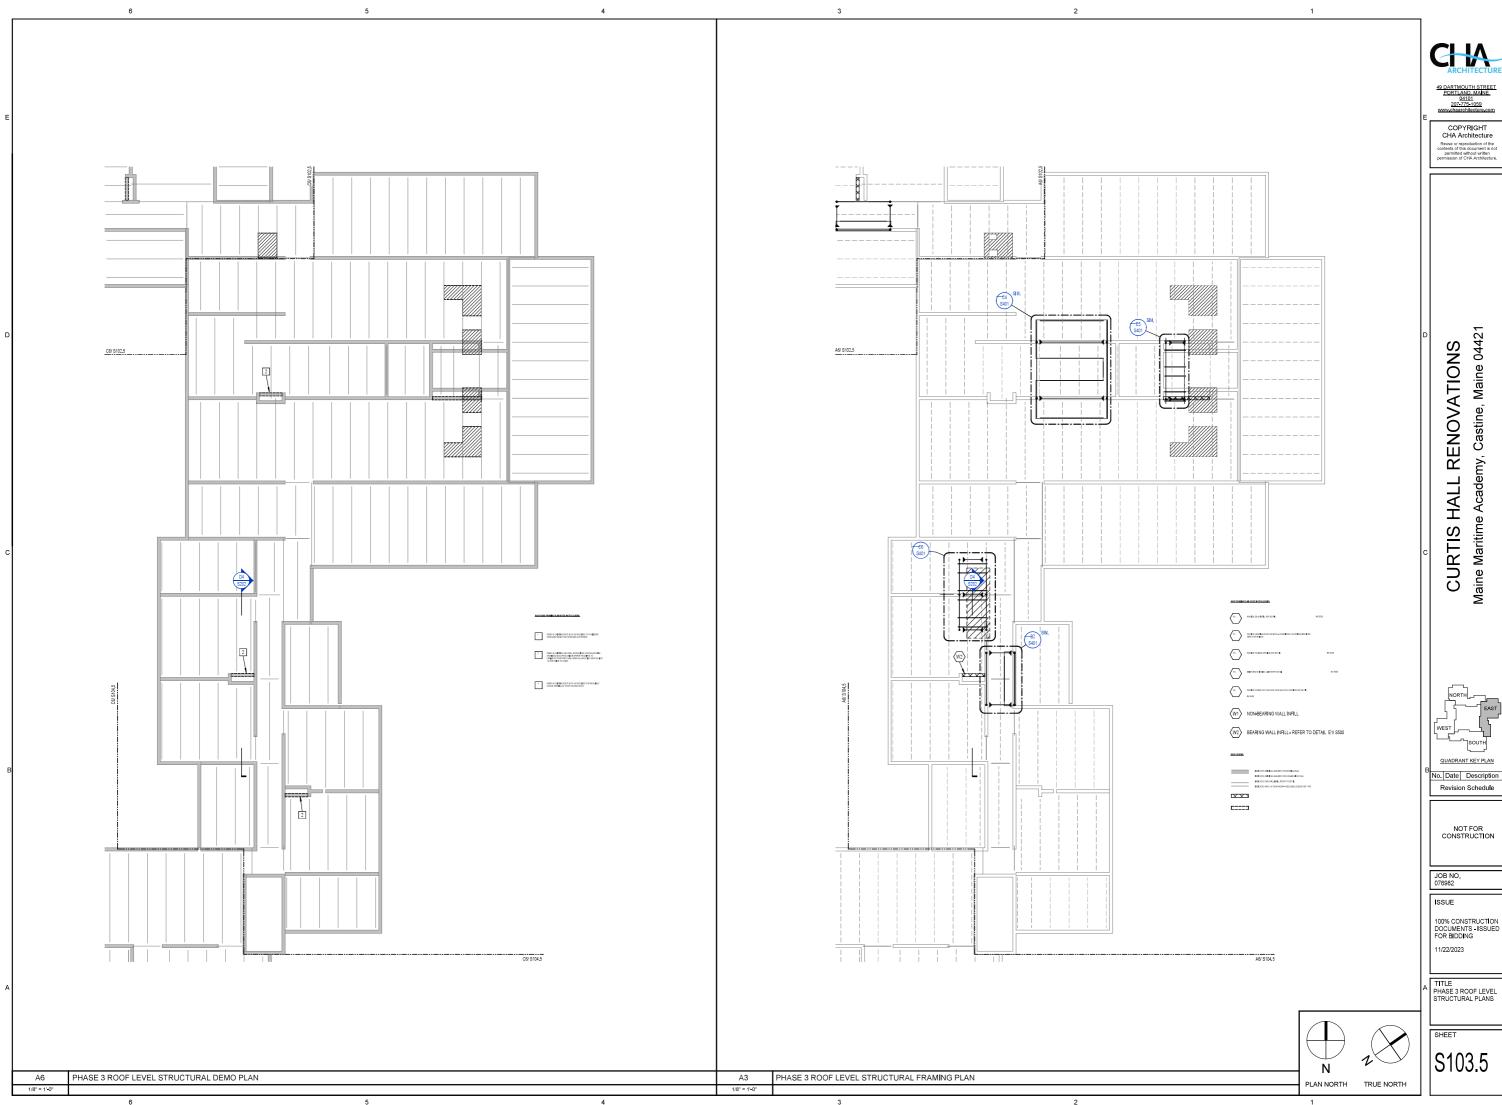











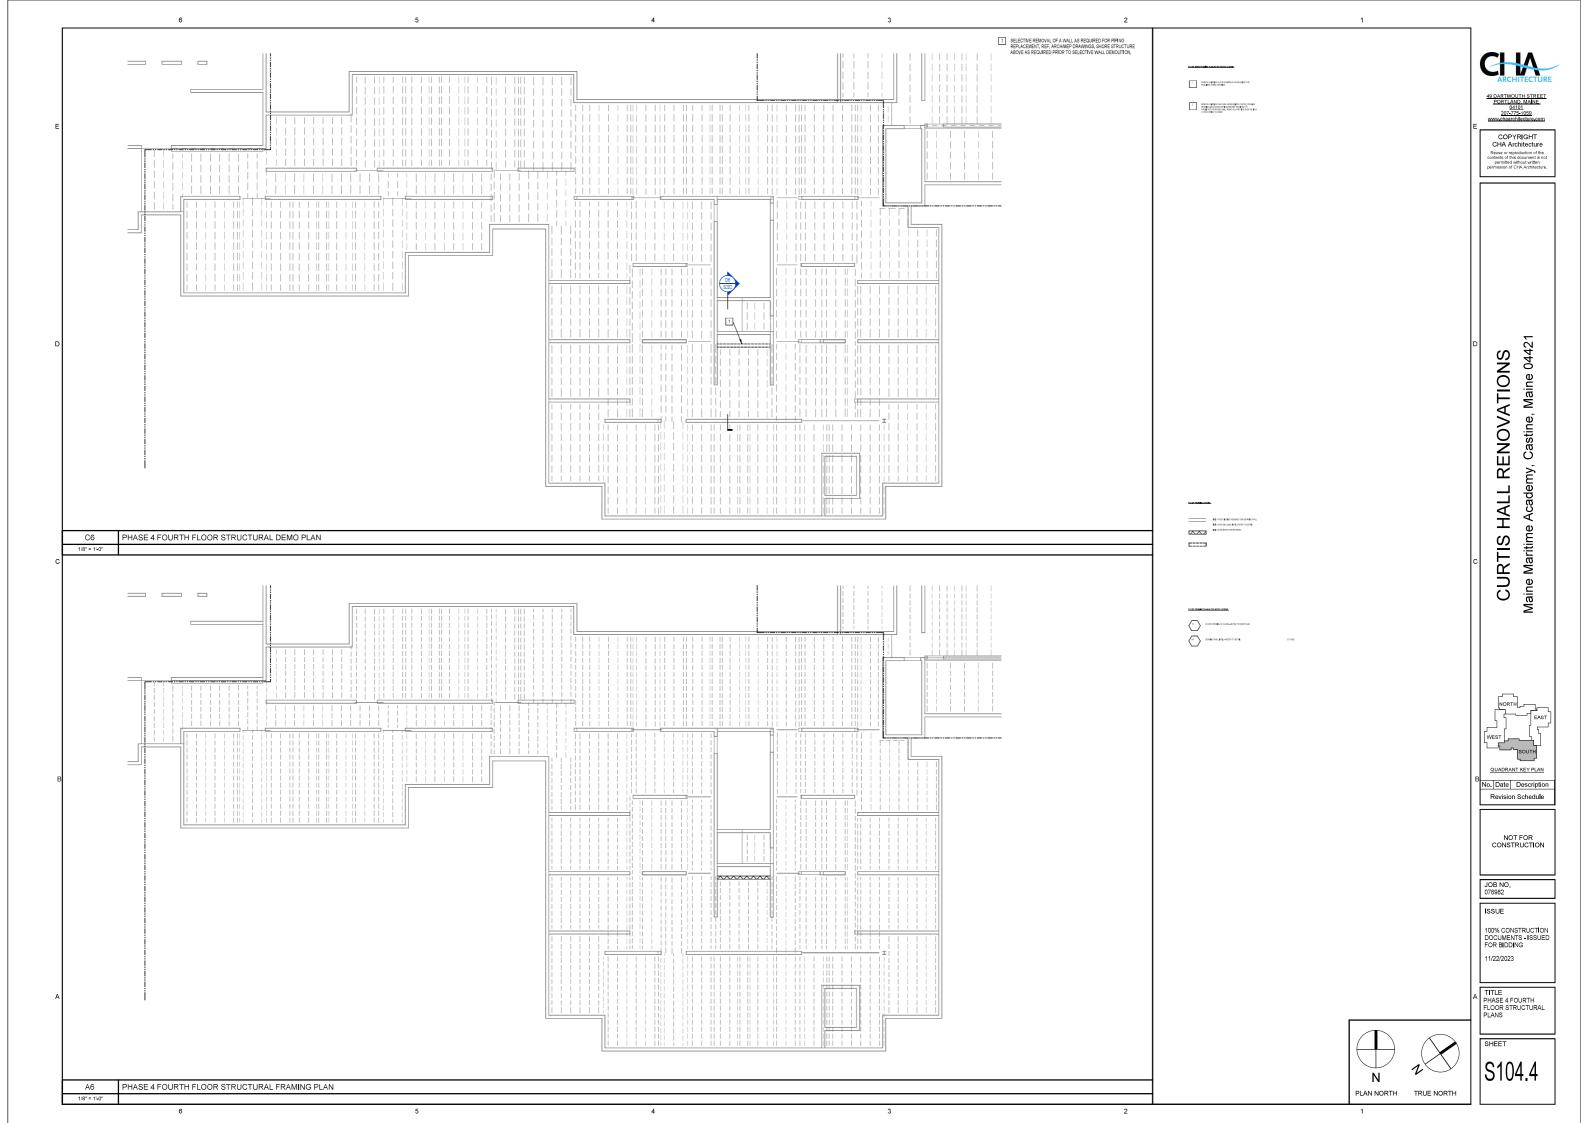


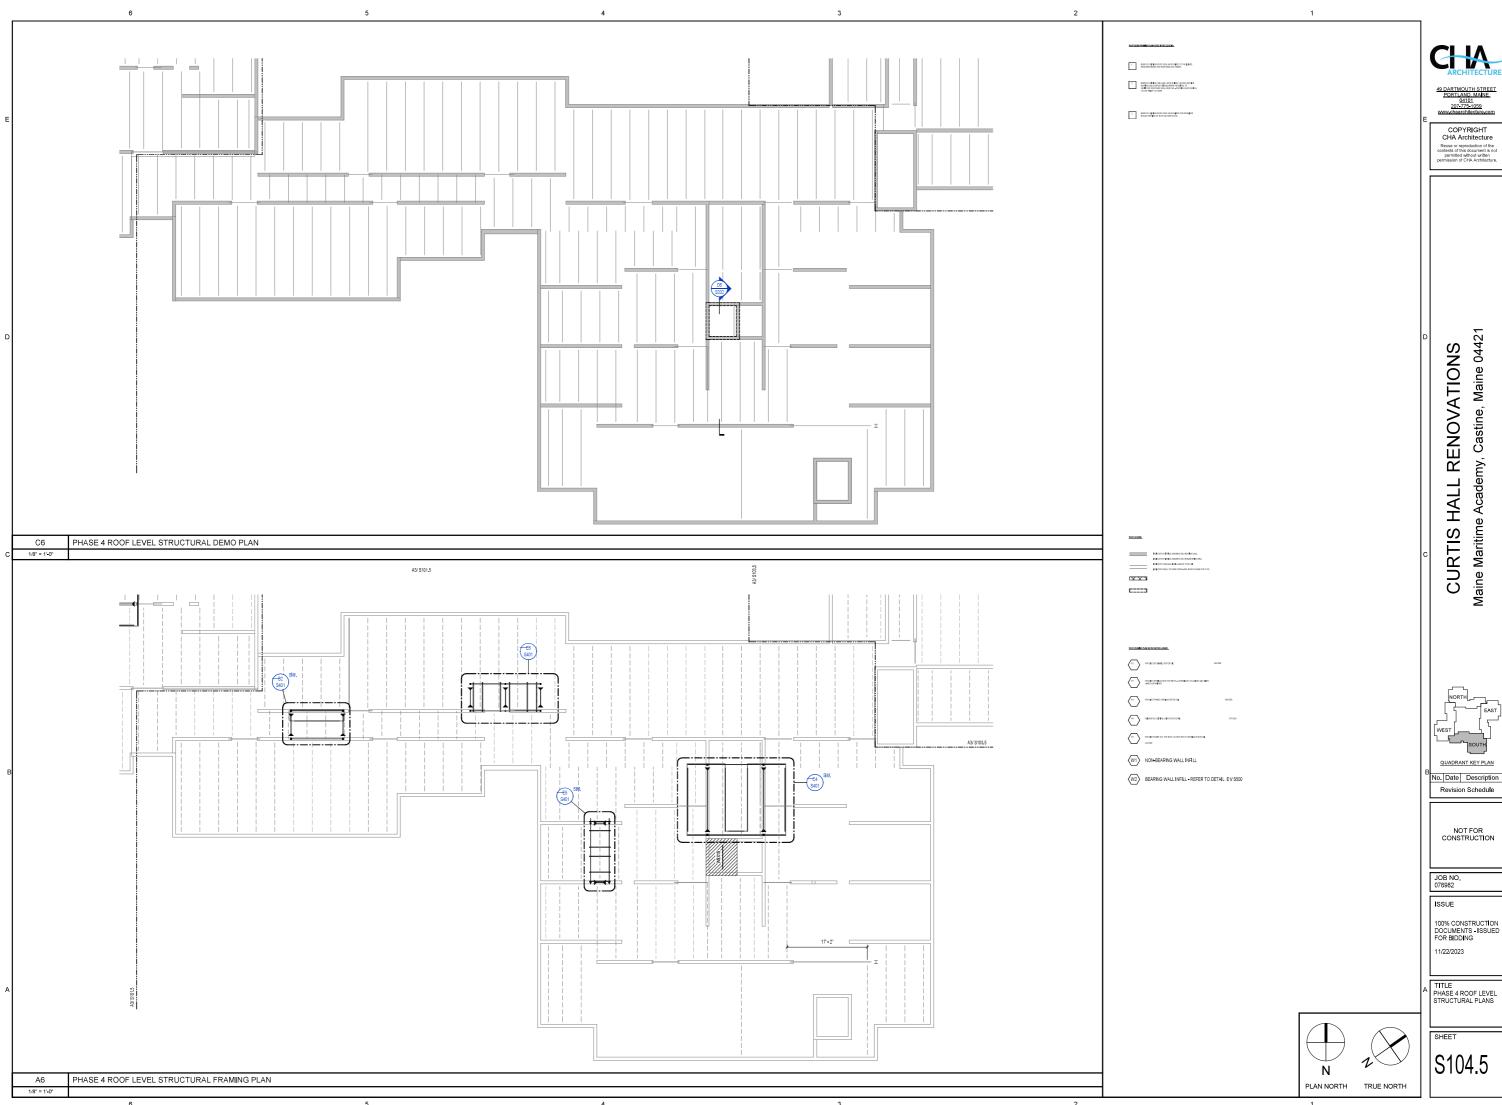


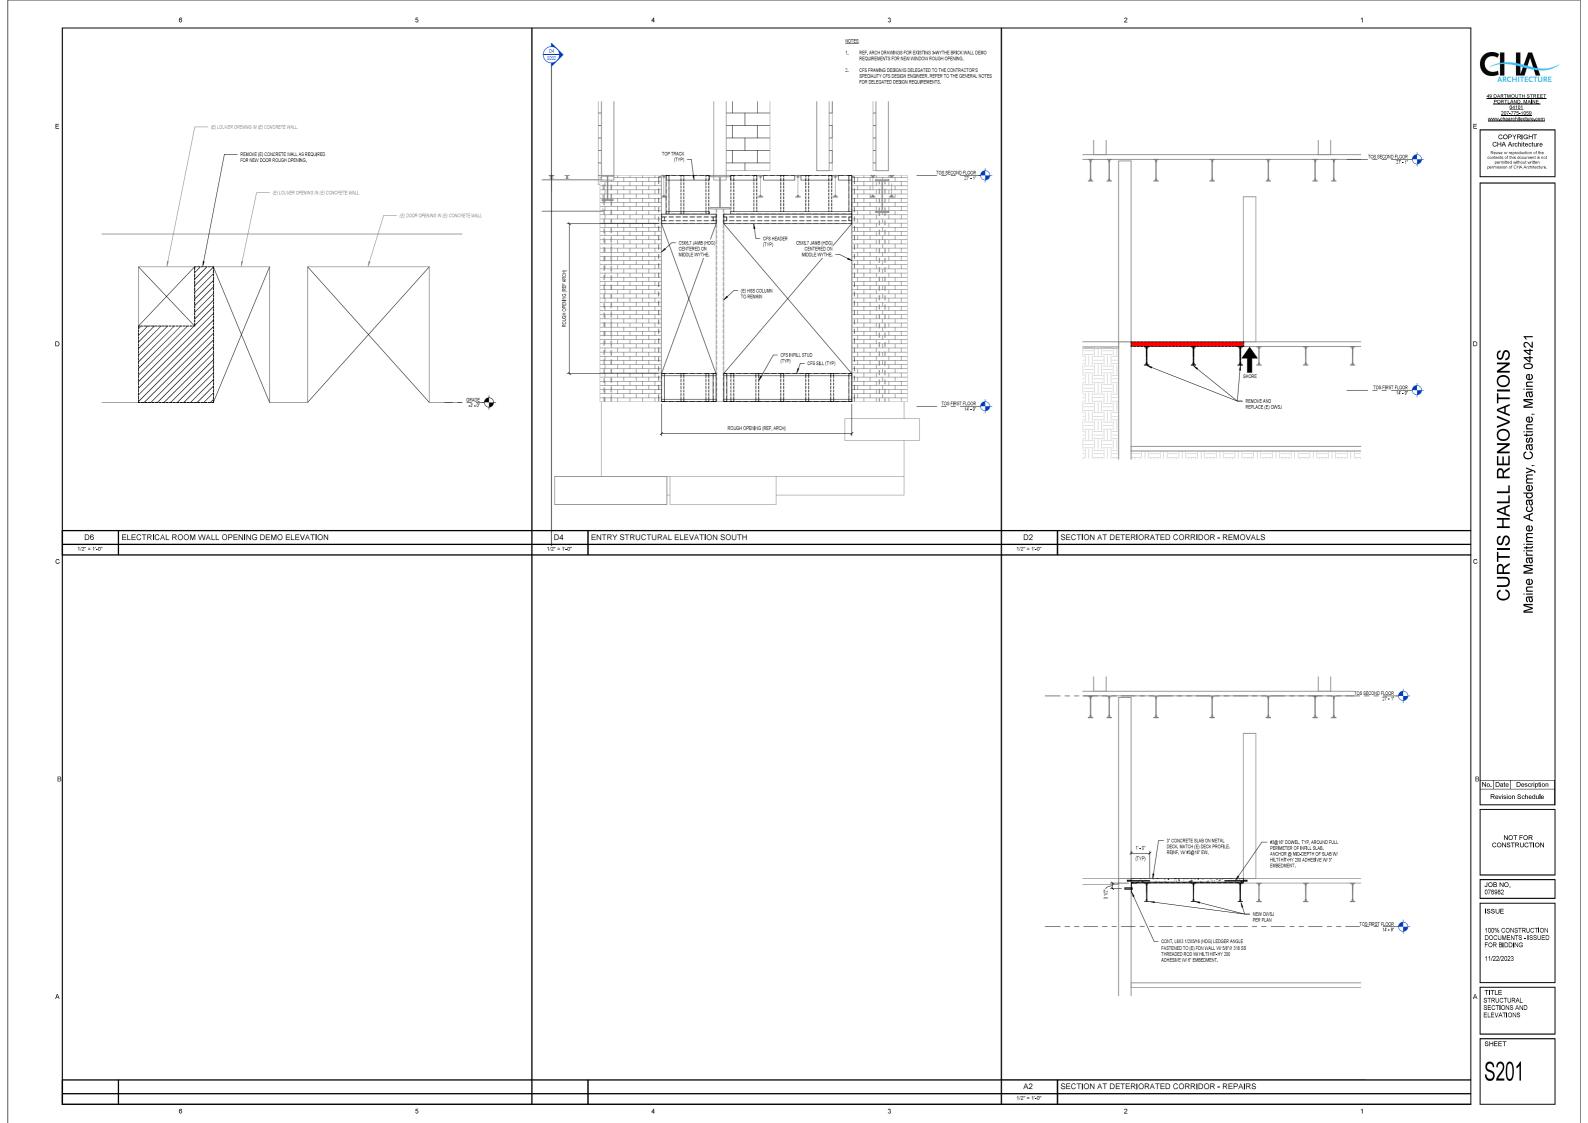


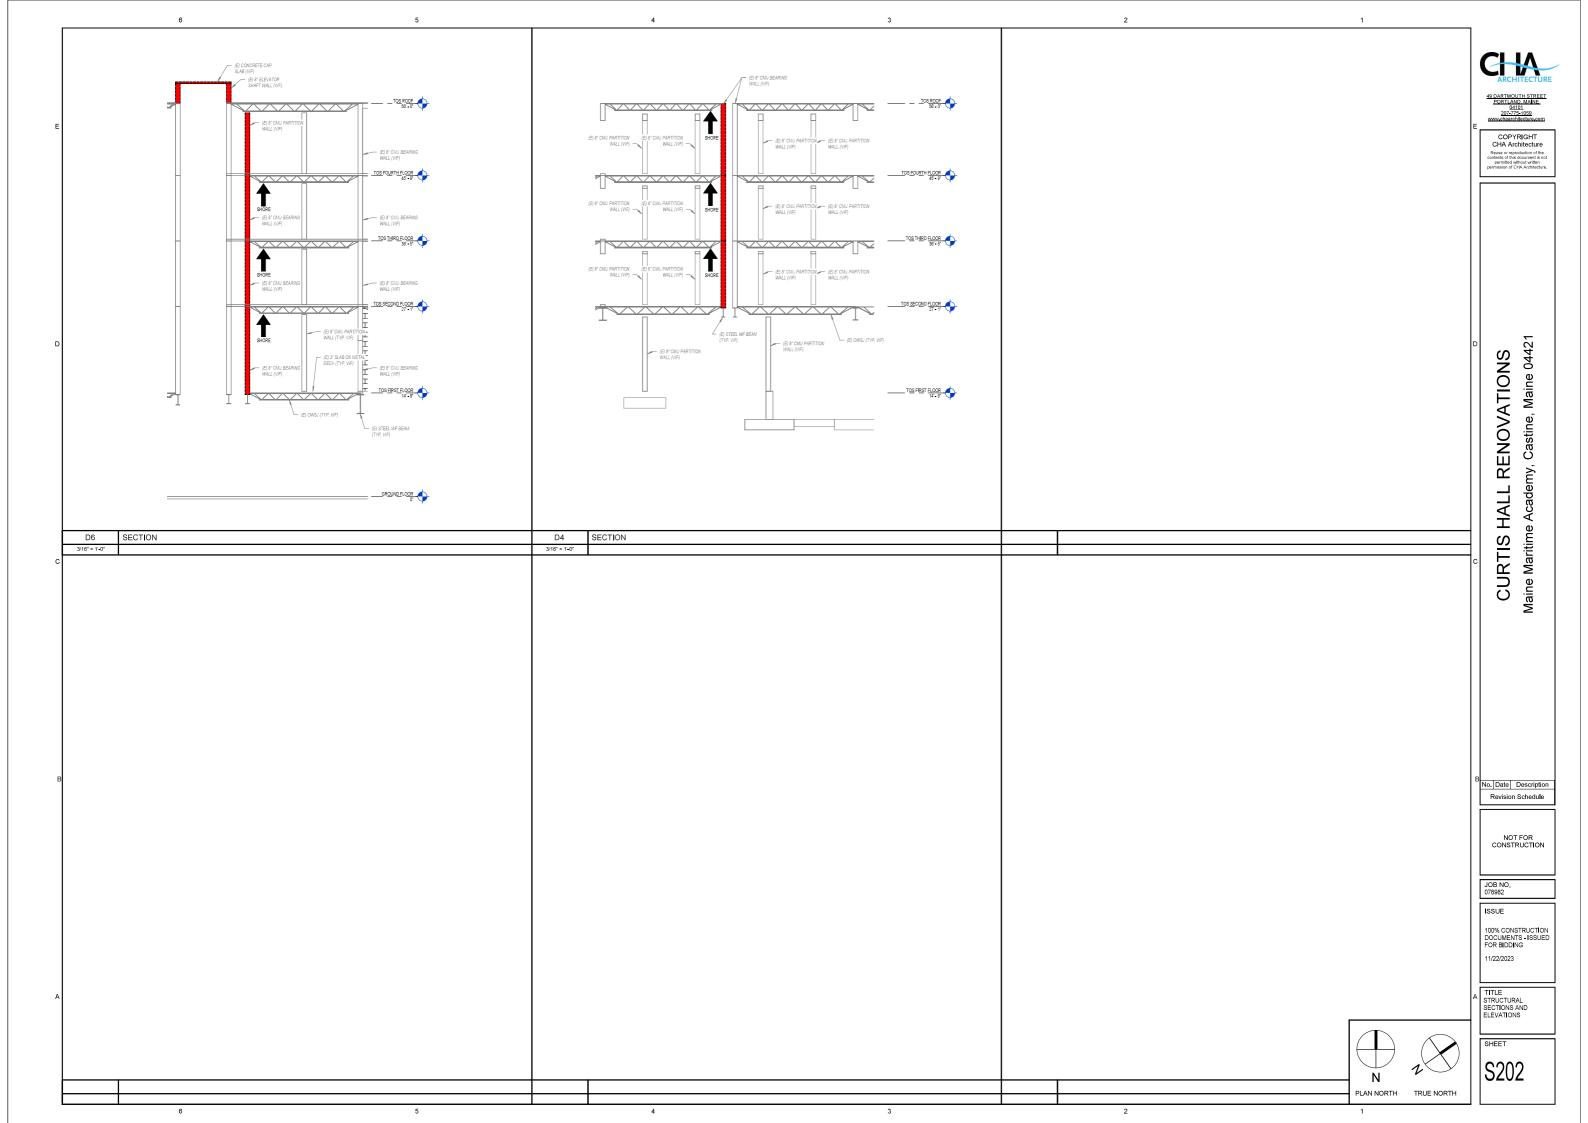

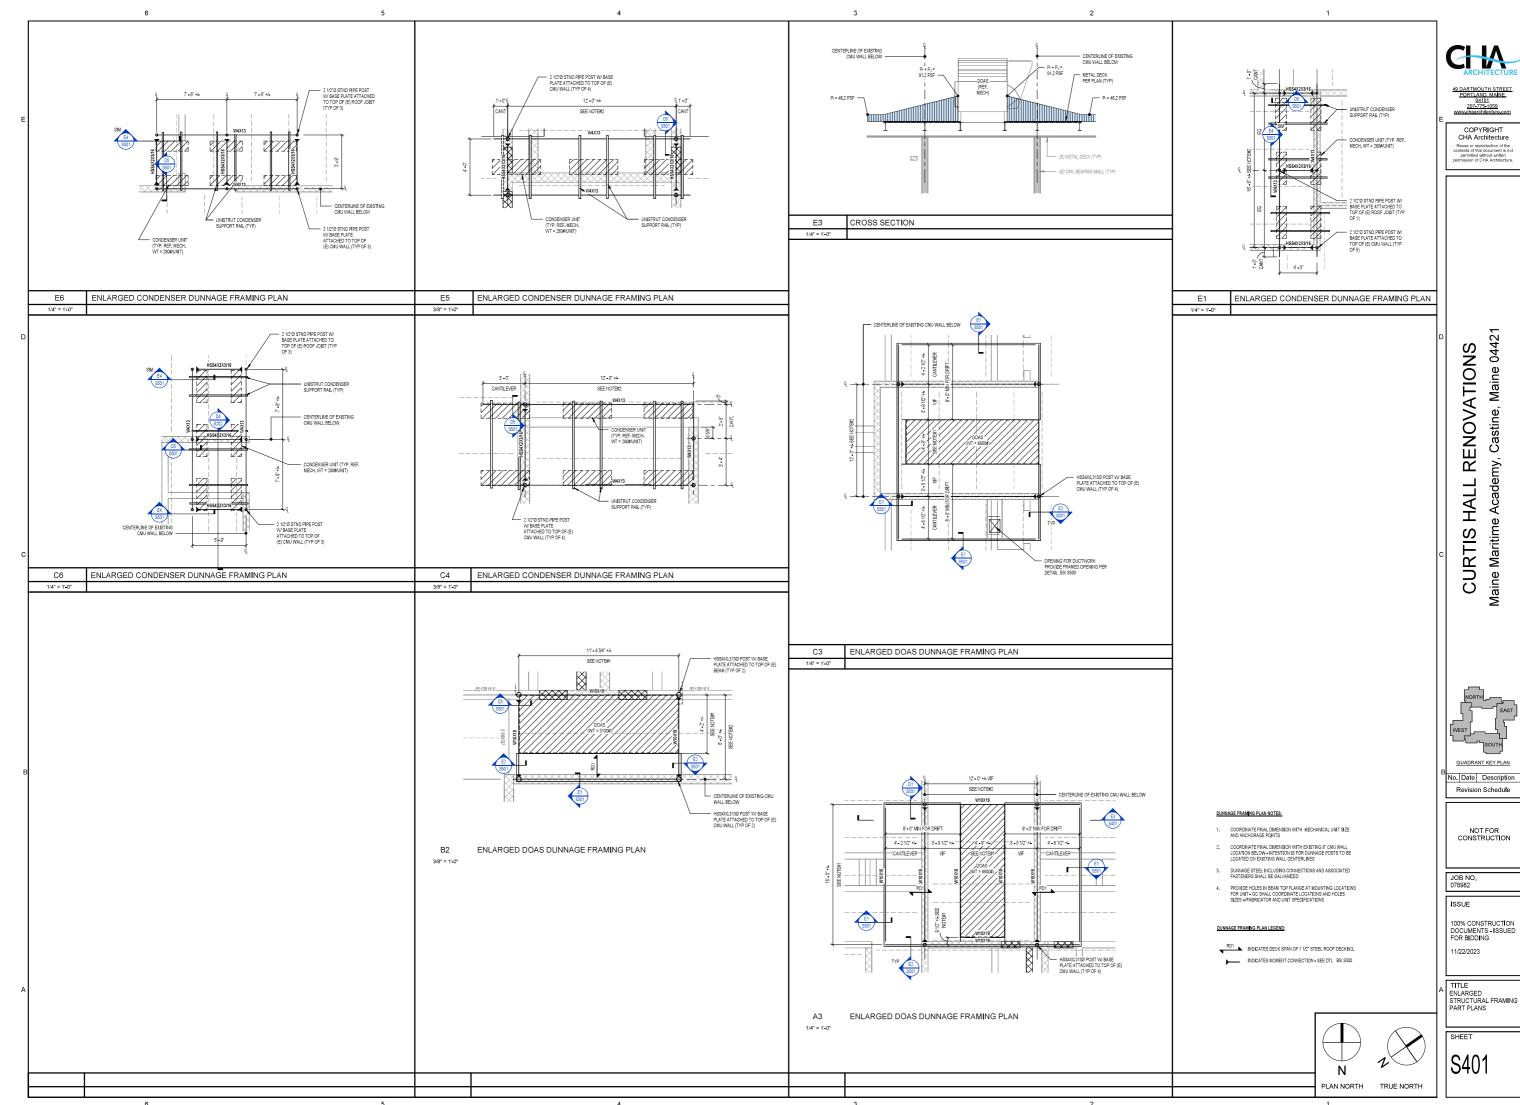

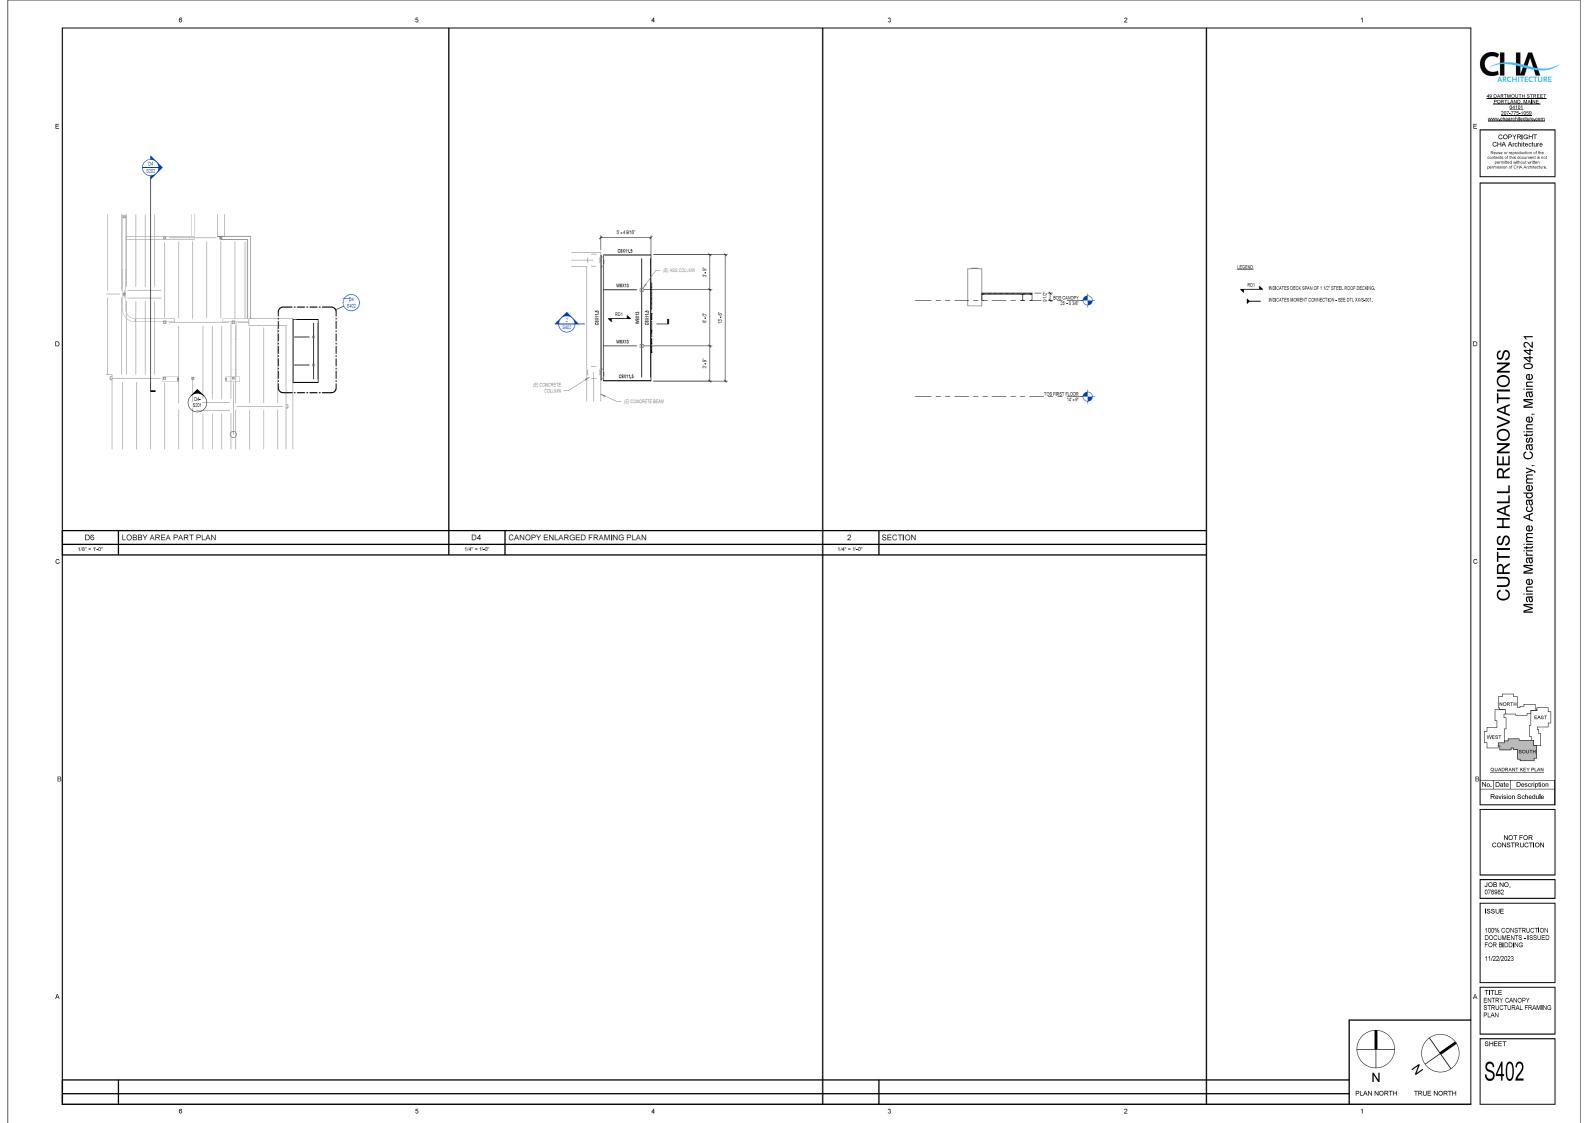

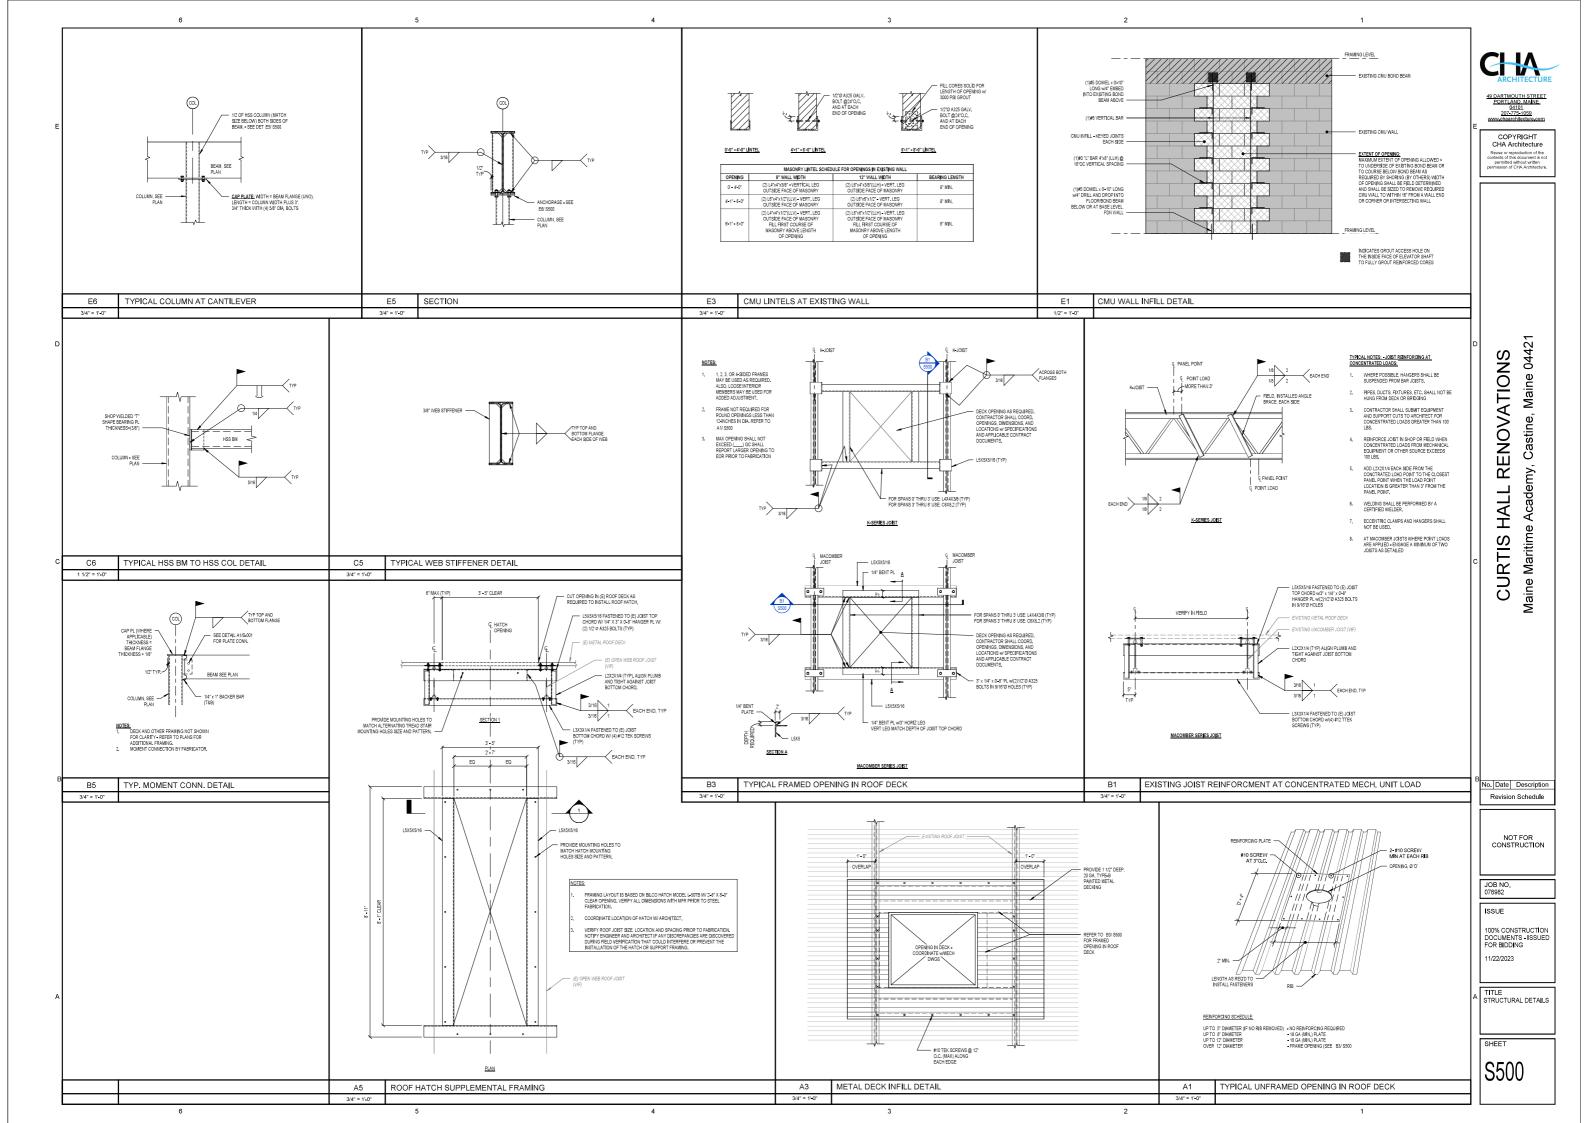

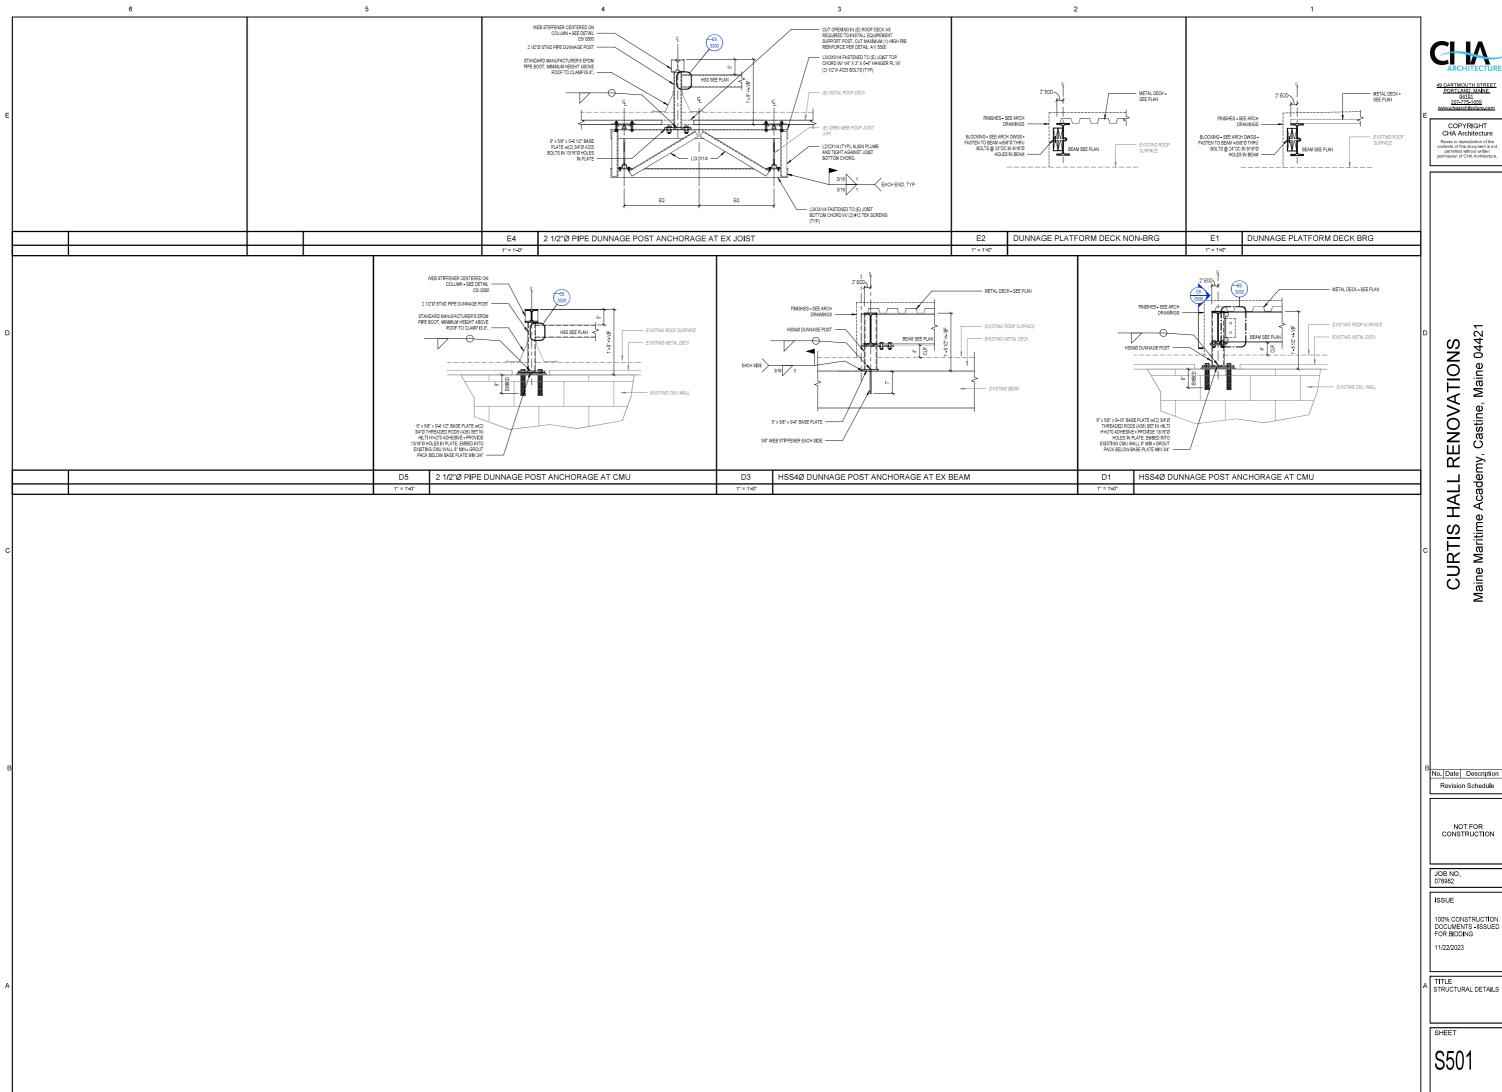

SPRINKLER NOTES:

- 1. THE CONTRACTOR, UNDER THE SCOPE OF THIS PROJECT, SHALL FURNISH AND INSTALL, BASED ON THE CURRENT SPRINKLER PIPING ARRANGEMENT, TWO 4"0 SUPERVISED ISOLATION VALVES WITAMPER SWITCHES AT EACH FLOOR OF THE FACILITY TO ENABLE ISOLATION OF HALF OF EACH FLOOR WHILE REMAINING AREAS REAMIN PROTECTED REFER TO SPECIFICATION SECTION 211000 FOR SPECIFICS.
- SPRINKLER COVERAGE AT ALL OCCUPIED SPACES SHALL REMAIN THROUGHOUT THE CONSTRUCTION PROJECT, REQUIRING THAT THE CONTRACTOR WORK AROUND LIVE SPRINKLER PIPPING WITHIN THE CONSTRUCTION ZONE, SHUT DOWNS AS REQUIRED TO FACILITATE SPECIFIED SPRINKLER REVISIONS SHALL BE STRICTLY SCHEDULED WITH MAINE MARITIME ACADEMY AND SHALL BE LIMITED TO SHUT DOWN OF ONE FLOOR OF ONE OCCUPIED QUADRANT IN ADDITION TO THE CONSTRUCTION AREA AT ANY ONE TIME.
- 3. SCHEDULED SHUT DOWNS SHALL BE LIMITED TO 8 HRS DURING NORMAL SUPERVISED CONSTRUCTION TIMES.

COPYRIGHT

CHA Architecture Reuse or reproduction of the ontents of this document is no permitted without written ermission of CHA Architecture

> S Hall 0442 ENOVATION , Curtis I Maine 0 Academy, Castine, N

 $\overline{\mathbf{C}}$ HALL Maine Maritime / Pleasant Street, \odot

R

No. Date Description

NOT FOR

Revision Schedule

CONSTRUCTION

JOB NO.

076982

ISSUE

100% CONSTRUCTION DOCUMENTS - ISSUED FOR BIDDING 1/22/2023

TITLE M-E-P PHASING NOTES

SHEET

MEP000

MEP General Phasing Requirements and Milestones

Phasing Document Development Notes:

- 1. Listed below is an outline/schematic version of an expected work/phasing plan. The general contractor will assemble a detailed work/phasing plan (with input from the respective system sub-contractors) for review and comment by the owner and the engineer of record prior to initiating any procurement/demoliton/construction effort. The general contractor will set up a work/phasing plan meeting to acquire input from the owner and the design team. The work/phasing plan will endude as a minimum each of the steps listed belaw, however, will elaborate with more detail, steps and information, include in the workplan each step beginning with investigation work and following through to beso-cut; step ID and description, approximate duration, if shit-down required, quantity of staff utilized, tools and equipment required for steps, systemstareas Boads at risk, contingency plans, staffstiop date (and time of day, if a staff of the steps of the staff of the staff

West Phase (Phase one)

- 1. Initiate re-tubing of one steam boler end of April 2024. Maintain other two steam bolers and associated systems related to the two out-buildings that they serve. Maintain steam/condensate to bookstore unit, systems related to the two out-buildings that they serve. Maintain steam/condensate to bookstore unit, beating pumps starting end of May 2024.
 2. Demo horizontal heating HWS/HWR mains, DHW/DCW/DHWR mains, above floor sanitary waste mains, astom water mains, and very liping throughout the West Phase area, starting in the boler room starting in May 2024.
 3. Demo all HWS/HWR/DCW/DHW/DHWR/Sanitary/Vert/Storm piping within the West Phase area, starting in the boler room starting in May 2024.
 4. Demo all HWS/HWR/DCW/DHW/DHWR/Sanitary/Vert/Storm piping within the West Phase area from Ground Floor up to the fourth floor starting in May 2024 and the starting in May 2024.
 5. Install new horizontal HWS/HWR, GWS/R, DCW, DHW, DHWR mains from the boler room through the Phase 1 areas, Valve and cap the mains at the Phase 2 at 6 bendaries for future connection to new piping in those phases, Provide temporary connection to existing Phase 2 and Phase 4 piping mains to facilitate temporary service for those phases from the new mains. Install vertical stable with valves for upper foor piping mains in the Phase 1 area, West horizontal piping mains charged and operational for August 2024, completed by January 2025.
 6. Remove Phase 1 nooftop exhaust fans serving bathrooms throughout that phase area.
 7. Remove Phase 1 nooftop exhaust fans serving bathrooms throughout that phase area.
 8. Remove Phase 1 nooftop exhaust fans serving bathrooms throughout that phase area.
 9. Remove Phase 1 nooftop exhaust fans serving bathrooms throughout that phase area.
 9. Remove Phase 1 nooftop exhaust fans serving bathrooms throughout that phase area.
 9. Remove exteam air handfer in the Phase 1 areas (electrical power from new panels, temporarily fed from existing electrical infrastructure).
 9. Remove exteam air handfer in the Phase 1 areas (ele

- power distribution equipment.
 20. Install new fire alarm devices (including NAC panels, batteries and power supplies needed to support new
- devices)

 Route the conduits needed for 400 Amp HVAC panels scheduled to be installed in phase two, three and four through the work zone of this phase, Extend respective conduits and install related feeders under the associated phase.

- 1. Demo horizontal heating HWS/HWR mains, DHW/DCW/DHWR mains, above floor sanitary waste mains, storm water mains, and vert piping throughout the Phase 2 areas, starting in January 2025
 2. Demo all HWS/HWR/DCW/DHW/DHW/RCantary/VertStorm piping within the North phase area from 2. The phase 2 areas was the horizontal HWS/HWR/DCW/DHW/DHW/RCantary/VertStorm piping within the North phase area from 3. Install new horizontal HWS/HWR, GW/SR, DCW, DHW, DHWR mains from the Phase 1 mains through Phase 2 areas to the Phase 3 boundary and provide temporary tie in to the existing mains in the Phase 3 area, with valves for isolation. This occurs primarily at the first-floor area with the exception of DHW which also serves the Phase 3 areas via horizontal piping through the Phase 2 area. Valve and cap the mains at the Phase 3 boundaries for future connection to new piping in that phase, Install vertical attures with valves for upper floor piping mains in the Phase 2 area. The existing pipe mains serving the Phase 3 area shall remain operational at attures, As such the existing promotorial mains serving these Phase 3 area shall remain in the properties of the pr

- panels and new infrastructure). Install new dryer vert exhaust fan for the Phase 2 areas. Install new VRF heat pumps throughout the Phase 2 areas (electrical power from new panels and new
- infrastructure). Install new generator, ATS, triple switch, transformer and make operational by August 2025. Re-feed west phase electrical distribution panels/panelboards from new switchgear and power distribution

- Re-feed west phase electrical distribution panels plandsboards from new switchager and power distribution infrastructure Summer 2025

 Test, adjust, balance, commission all new MEP systems within the north phase and new electrical infrastructure for August 2025. Adjust heating hot water pump pressure setpoints as required. Install new entering lighting and controls (lose and alternates as selected at contract). Install new exit signs and emergency egress lighting systems; Install new exit signs and emergency egress lighting systems; Install new exit on the production of the produc
- Wire new rooftop HVAC equipment to new 400 Amp panel; wire other HVAC loads to existing and replaced power distribution equipment
 Install new fire alarm devices (including NAC panels, batteries and power supplies needed to support new
- devices)

 19. Route the conduits needed for 400 Amp HVAC panels scheduled to be installed in phase three through the work zone of this phase. Extend respective conduit and install related feeder under the associated phase.

East Phase (Phase three)

- 1. Denn bortoortal heating HWS/HWR mains, DHW/DCW/DHWR mains, above floor sanitary waste mains, storm water mains, and vert piping throughout the Phase 3 area, starting in May 2025.
 2. Denno all HWS/HWR/DCW/DHW/DHW/BR/SIAIP/Vert/Storm piping within the Phase 3 area from ground floor up to the fourth floor starting in May 2025.
 3. Install never hortoortal HWS-HWW, GWS/R, CW, DHW, DHWR mains from the hortcortal Phase 2 mains upper floor piping mains in the Phase 3 area.
 4. Replace all HWS/HW/DCH/DW/DW/BW/RS-antary/Storm/Vert priping throughout the Phase 3 areas to be completed by August 2025.
 5. Remove Phase 3 rooftop exhaust fans serving bathrooms throughout that phase area.
 6. Install new DCAS/ERV units and associated ductwork to serve the Phase 3 area (electrical power from new panels and reverse the pumps throughout that phase area.
 8. Install new VIKF heat pumps throughout the East Phase area (electrical power from new panels and reverse pumps and the pumps throughout the East Phase area (electrical power from new panels and new infrastructure).

- Install new VRF heat pumps throughout the East Phase area (electrical power from new panels and new infrastructure).
 Complete MEP installations throughout the renovated Quarter Deck area.
 Complete MEP installations throughout the renovated Parks within the east phase for January 2026. Adjust heating hot water pump pressure selpoints as required.
 Install new interior [pithing and controls (base and alternates as selected at contract)
 Install new exit signs and emergency genes lighting (sighternate).
 Install new exit of the properties of the
- power distribution equipment

 17. Install new fire alarm devices (including NAC panels, batteries and power supplies needed to support new

South Phase (Phase four)

- 1. Demo horizontal heating HWS/HWR mains, DHW/DCW/DHWR mains, above floor sanitary waste mains, storm water mains, and vert piping throughout the Phase 4 area, starting in January 2025.

 2. Demo all HWS/HW/BC/DCW/HWD/HWS/RAINAry/Vert/Storm piping within the Phase 4 area from ground floor up to the fourth floor starting in January 2025.

 3. Replace all HWS/HW/BC/DW/DW/DW/RS/antary/Storm/Vert piping throughout the Phase 4 area.

 4. Replace all HWS/HW/BC/HWD/DW/DW/RS/antary/Storm/Vert piping throughout the Phase 4 area.

 5. Remove Phase at rooftop exhaust fains serving bathrooms throughout the Phase 4 area.

 6. Install new DOAS/ERV units and associated ductwork to serve the Phase 4 area (electrical power from new panels and new infrastructure into first the Phase 4 area.

 7. Install new VKF heat pumps throughout the Phase 4 area (electrical power from new panels and new infrastructure into first the Phase 4 area.

 8. Install new VKF heat pumps throughout the Phase 4 area (electrical power from new panels and new infrastructure).

- 8. Install new VRF heat pumps throughout me Phase a draw (see a support and the pass of t

- power distribution equipment

 16. Install new fire alarm devices (including NAC panels, batteries and power supplies needed to support new

- Prior to conducting demolition of HWS/HWR piping/systems, the contractor shall document the operating head of the existing hot water heating pumps,
 Upon installation of new hot water heating pumps, the contractor shall set the system D.P. to maintain that of the existing system to ensure flow to all "Future Phases" as currently exists.
 Once Phase 4 is complete and all new piping and systems are operational, the contractor shall adjust the system D.P. based upon actual system requirements.

General Phased Hydronic Balancing Notes

NOTE; WORK ON THIS PROJECT SHALL BE COMPLETED IN 4 SCHEDULED CONSTRUCTION PHASES, WHILE CONSTRUCTION IN ANY GIVEN PHASE IS ACTIVE, MAINE MARITIME ACADEMY WILL CONTINUE TO OCCUPY THE REMAINING 3 INACTIVE PHASES.

THE CONTRACTOR IS RESPONSIBLE FOR MAINTAINING ALL SERVICES (INCLUDING BUT NOT LIMITED TO DOMESTIC WATER SUPPLY, HYDRONIC SUPPLY & RETURN, RAIN WATER DRAINAGE, VENT SYSTEMS, ETC., TO INACTIVE PHASES DURING CONSTRUCTION, THE METHOD SHOWN BELOW IS ONE THAT CAN BE USED TO MAINTAIN PIPED SERVICES TO ADJACENT PHASES BUT OF THAT CAN BE USED TO MAINTAIN PIPED SERVICES TO ADJACENT PHASES BUT OF THAT CAN BE USED TO MAINTAIN PIPED SERVICES TO ADJACENT PHASES BUT OF THAT OF THE VIBER OF THE CONTRACTOR MEETS THIS RESPONSIBILITY.

ANY INTERRUPTIONS IN SERVICE TO OCCUPIED AREAS OF THE BUILDING SHALL BE STRICTLY COORDINATED WITH MAINE MARITIME ACADEMY.

	ACTIVE PHASE (UNDER CONSTRUCTION)	SOUNDARY FUTURE PHASE OCCUPIED BY MMA)	STEPS FOR MAINTAINING PIPED SERVICE ACROSS MULTIPLE PHASES
1	}(Ε)	(E)——	DO NOT REMOVE EXISTING PIPE MAIN WITHIN ACTIVE PHASE UNTIL TEMPORARY SERVICE HAS BEEN EXTENDED TO FUTURE PHASE.
2	}(E)	B X vc (E)	2. INSTALL THE NEW PIPE MAIN AT THE ACTIVE PHASE AND EXTEND PIPE (WITH AS LITTLE IMPACT AS POSSIBLE) INTO FUTUR! PHASE, WITHIN THE FUTURE PHASE, PROVIDE A BRANCH SIZED THE SAME AS THE MAIN, VALVES "A" & "B" AND CAPS,
3	}(E)	B Xw	3. ONCE THE NEW MAIN IS OPERATIONAL, SCHEDULE A TEMPORARY SERVICE SHUTDOWN AT THE FUTURE PHASE TO CONNECT THE EXISTING MAIN TO THE TEMPORARY SERVICE BRANCH.
4	¿	B No	4. OPEN VALVE "8" TO PROVIDE SERVICE T THE FUTURE PHASE, THE SECTION OF EXISTING PIPE MAIN IN THE ACTIVE PHASE CAN NOW BE REMOVED.
5	PREVIOUSLY COMPLETED PHASE (OCCUPIED BY MMA)	ACTIVE PHASE——— (UNDER CONSTRUCTION) TO DE MINO (N)——— A (N)————————————————————————————————————	5. WHEN THE FUTURE PHASE BECOMES ACTIVE, EXTEND THE NEW PIPRING MAIN INTO THE PHASE WHER KEEPING VALVE "CLOSED, CLOSE VALVE" B" TO HALT SERVICE AND REMOVE EXSTINO PIPRING. WHEN NEW WORK IS COMPLETE, OPEN VALVE "A" TO REST
	(E) EQUIPMENT TO REMAIN OR BE REPLACED NEW BRANCH (N)	REMOVE (E) BRANCH TO PHASE BOUNDARY AND CAP	IN SOME INSTANCES, EXISTING BRANCH PIPING WITHIN A FUTURE PHASE MAY SERVE EXISTING EQUIPMENT OR FIXTURES IN AN ACTIVE PHASE, WHERE THIS CCCURS, REMOVE (E) BRANCH HIPING IN THE ACTIVE PHASE TO THE EXTENT POSSIBLE WITHOUT DISKUPLIFING SERVICE TO THE FUTURE FURSA AND REFACE OF THE FUTURE PHASE AND REMOCH WITHIN THE ACTIVE PHASE.

M-E-P PHASING NOTES

A6

NONE

DIAGRAM - MAINTAINING PIPED SERVICES TO ADJACENT PHASES A2

ACCESS PANEL NOTE: ISOLATION VALVES CONTROL VALVES CONTROL VALVES
ACTUATORS
VOLUME DAMPERS
SHOCK ARRESTORS
SOLENOID VALVES
CONTROL TRANSFORMERS
CONTROLLERS
FIRE AND SMOKE DAMPERS ACCESS PANELS SHALL BE SIZED TO PROMOTE ADEQUATE ACCESS TO THE DEVICE SERVICED - 12"X12" MINIMUM, ADDITIONALLY, ACCESS PANELS (24"X24") SHOULD BE INSTALLED FOR ACCESS TO ALL PLUMBING CHARES. HVAC AND PLUMBING NOTES E6 NONE EXPANSION LOOP CHANGE IN ELEVATION - UP DOWN, RISE OR DROP MOTORIZED DAMPER REGISTER, GRILLE & DIFFUSER TAG PIPE ELBOW TURNED DN ______ GLOBE VALVE EXPANSION LOOP (BRAIDED/MANUFACTURED) PIPE ELBOW TURNED UP ___O LOCKABLE BALL VALVE -QUANTITY -CFM AIR FLOW FLEXIBLE CONNECTION PIPING TEE DOWN SUPPLY DUCT TURNED UP / DN —,4 FLOOR DRAIN FINTUBE TAG PIPING TEE UP TEMPERATURE SENSOR OR THERMOSTAT (AS SPECIFIED T SHOCK ABSORBER - WATER HAMMER ARRESTER RETURN DUCT TURNED UP / DN 2-WAY CONTROL VALVE _____SA__ 0 PIPE RISER HUMIDISTAT OR HUMIDITY SENSOR (AS SPECIFIED) Θ ___ 3-WAY CONTROL VALVE GAS SHUT-OFF VALVE EXHAUST DUCT TURNED UP / DN FIRE DEPARTMENT - WALL MOUNTED CONNECTION (Co2) CARBON DIOXIDE SENSOR PIPING TO BE REMOVED LOCK & SHIFLD VALVE ROUND DUCT TURNED UP / DN © CARBON MONOXIDE SENSOR CAPPED PIPING __*_ v FIRE DEPARTMENT - FREESTANDING CONNECTION _____ MITERED DUCT ELBOW w/ TURNING P PRESSURE SENSOR EQUIPMENT TAG —× AP ACCESS PANEL Ū ECCENTRIC REDUCER £ FIRE DEPARTMENT - WATER GONG THERMOMETER W/ COCK ____<u>\</u> AIR VENT ~ REFER TO SPECIFICATIONS DUCTWORK ~ FIRST DIMENSION IS SIDE SHOWN IN INCHES S=SUPPLY, R= RETURN, E= EXHAUST AIR, OA= OUTSIDE AIR 1,O, = FLAT OVAL DSD DIRECTION OF FLOW DUCT SMOKE DETECTOR RADIUS DUCT ELBOW EQUIPMENT TAG (ON FLOOR/ROOF ABOVE)

TYPE DESIGNATOR SOLENOID VALVE __ 12x8S (EF-ROOFTOP EXHAUST FAN STRAINER W/ BLOWDOW VALVE AND CAP ORIFICE FLOWMETER DUCT / PIPE CAP- SINGLE / DOUBLE LINE PIPE GUIDE ĬĬ⟩_{SF-} DETAIL REFERENCE SYMBOL - DP ___ EXPANSION VALVE - AUTOMATIC \boxtimes CEILING DIFFUSER ~ 4-WAY BLOW SHEET DETAIL LOCATED ON VOLUME DAMPER HVVVV HUMIDIFIER - DUCT / AHU MOUNTED RELIEF / SAFETY VALVE \boxtimes CEILING DIFFUSER ~ 3-WAY BLOW UNION FINNED TUBE BASEBOARD DUCTWORK TO BE REMOVED SECTION REFERENCE SYMBOL \times PRESSURE GAUGE w/ COCK FIRE DAMPER SECTION No. HBWILLYD -SHEET SECTION LOCATED ON BACKFLOW PREVENTER $- \infty$ SIGHT GLASS SINGLE LINE DUCTWORK TO BE REMOVED ____ FLOOR CLEANOUT PRESSURE REDUC**I**NO VALVE FLEXIBLE CONNECTION DUCT TRANSITION CEILING EXHAUST GRILLE SHUT-OFF / ISOLATION VALV REFER TO SPECIFICATIONS ——

FUSIBLE LINK VALVE FLOW SWITCH FIRE AND SMOKE DAMPER SQUARE TO ROUND DUCT TRANSITION POINT OF CONNECTION - EXISTING TO NEW SELF-CONTAINED TEMPERATURE CONTROL VALVE w/ REMOTE SENSOR FLEX DUCT ~ DOUBLE LINE DIRECTION OF AIR FLOW c-~~~~ FLEX DUCT ~ SINGLE LINE CURTIS SYMBOLS LEGEND NONE LIQUID NITROGEN ACID WASTE FORCE MAIN AAV AUTOMATIC AIR VENT CU COPPER; CONDENSING UNIT NOT IN CONTRACT TTS TIGHT TO STEEL ATV AIR RELIEF ABOVE CEILING CABINET UNIT HEATER NATIONAL PIPE THREAD TURNING VANE GENERAL CONTRACTOR LIQUID PETROLEUM GA BOILER BLOWDOWN NOT TO SCALE OPPOSED BLADE DAMPER OUTSIDE AIR OUTSIDE DIAMETER ACC GALLONS PER MINUTE TEMPERED WATER AIR COOLED CONDENSER C.V. CONTROL VALVE CONDENSATE (HVAC DRAIN PAN) LOW PRESSURE CONDENSATE TYPICAL COLD WATER; CLOCKWIS GRAVITY ROOF VENTILATO ACU AIR CONDITIONING UNIT LOW PRESSURE STEAM COMPRESSED AIR DRY BULB TEMPERATURE HUMIDIFIER UNIT HEATER ADA AMERICANS WITH DISABILITIES ACT MEDICAL AIR OPEN ENDED DUCT CHILLED WATER RETURN DOUBLE CONTAINED HOSE BIBE ACCESS DOOR AD ——MPR —— MEDIUM PRESSURE CONDENSATE PLUMBING FIXTURE TAG CHILLED WATER SUPPLY DDC DIRECT DIGITAL CONTROL HANDICAP ACCESS UP IN WALL ACID EXHAUS MEDIUM PRESSURE STEAM PUMPED DISCHARGE ----CTR ---- COOLING TOWER RETURN DET DETAIL HGT: HT HEIGHT UNIT VENTILATOR ACID WASTE MAKE-UP WATER PROCESS PIPING ____ств ____ COOLING TOWER SUPPLY DIA DIAMETER HP HEAT PUMP VENT ABOVE FINISHED FLOOR NITROGEN PRESSURE REDUCING STATION DOWN IN CHAS ----CWR----CONDENSER WATER RETURN HEAT RECOVERY UNIT VAC VACUUM AIR HANDLING UNIT NATURAL GAS DOWN IN WAL HEATER CONDENSER WATER SUPPLY AP ACCESS PANEL VB VACUUM BREAKER RETURN AIR DOWN DOMESTIC COLD WATER (DCW) APPROX. APPROXIMATE: APPROXIMATELY VCFF VALVE & CAP FOR FUTURE NON-POTABLE WATE ROOF DRAIN HEATING, VENTILATING AND AIR COND. DOMESTIC HOT WATER (DHW) APMR AS PER MFR'S RECOMMENDATIONS VD VOLUME DAMPER - MANUAI ____ov___ OXYGEN RECOMMENDATION DOMESTIC HOT WATER RECIRC. (DHWR) DROP AND TRANSITION HW HOT WATER VALVE ATC AUTOMATIC TEMPERATURE CONTROL ——РС—— PUMPED CONDENSATE REGULAR DV DRAIN VALVE HWR HOT WATER RETURN VENT STACE DRAIN AV AIR VENT RETURN FAN PCWR— PROCESS COLD WATER RETURN DWG DRAWING HWS HOT WATER SUPPLY VENT TO ROO PUMP FORCE MAIN BALANCING COCK RETURN GRILLE PROCESS COLD WATER SUPPLY EXHAUST AIR HEAT EXCHANGER BDD BACKDRAFT DAMPE FUEL OIL FILL ——RD—— REFRIGERANT DISCHARGE EXHAUST FAN INSIDE DIAMETER WITH FUEL OIL RETURN BLAST GATE ——RL —— REFRIGERANT LIQUID INCHES WATER GAUGE EXHAUST GRILLE WB WET BUILD TEMPERATURE °F BARRIER FREE FUEL OIL SUPPLY REDUCED PRESSURE BFP ——RS—— REFRIGERANT SUCTION INCLUDING ELEV BACKFLOW PREVENTER wco WALL CLEANOUT FUEL OIL TANK VENT RETURN REGISTER REVERSE OSMOSIS WATER INV. EL. INVERT ELEVATION BRAKE HORSEPOWER WATER HEATER FEEDWATER RELIEF VALVE RAIN WATER - ABOVE FLOOR IRON PIPE SIZE ENCLOSURE WALL HYDRANT BLDG BUILDING ——GR—— GLYCOL RETURN RAIN WATER KITCHEN EQUIPMENT NUMBER EXHAUST REGISTER KE-# BOD BOTTOM OF DUCT SUPPLY AIR RAIN WATER OVERFLOW - ABOVE FLOOR LINEAR DIFFUSER ENERGY RECOVERY UNIT B,T,U, BTU BRITISH THERMAL UNIT SHOCK ABSORBER OF PDI SIZE ("") AS INDICATED GREASE LADEN VENT RAIN WATER OVERFLOW - BELOW GRADE SCIENCE LAB EQUIPMENT NUMBER ESP EXTERNAL STATIC PRESSURE AND CONDENSATE SPRINKLER MAIN PIPING GREASE LADEN WASTE CONV. CONVECTOR ET EXPANSION TANK LIQUID PETROLEUM GAS SELF-CONTAINED VALVE PERCENT GEOTHERMAL WATER RETURN ____swr___ SOLAR WATER RETURN CCW COUNTER CLOCKWIS LOW PRESSURE STEAM RETURI SMOKE DAMPER (E) EXISTING GEOTHERMAL WATER SUPPLY SOLAR WATER SUPPLY CFF CAPPED FOR FUTURE SUPPLY FAN F&T FLOAT AND THERMOSTATIC LPS LOW PRESSURE STEAM SUPPLY HUMIDIFICATION LINE ---TP--- TRAP PRIMER - ABOVE FLOOR CFM CUBIC FEET PER MINUTE SUPPLY GRILLE ISSUE FURNISHED BY OTHERS FBO MAX MAXIMUM ---TP--- TRAP PRIMER - BELOW GRADE HYDROGEN GAS CLG CELLING FACE AND BYPASS MBH 1000 BTUH/hr. TEMPERED WATER RETURN HEAT/COOL RETURN CO CLEANOUT SHEET FLEXIBLE CONNECTION MFR MANUFACTURER TEMPERED WATER SUPPLY CONSTRUCTION MANAGER ——нся —— HEAT/COOL SUPPLY CM SPLR SPRINKLER MINIMUM MIN SANITARY SOIL VENT - ABOVE FLOOR CNTR COUNTER; COUNTER TO FLOOR DRAIN TAG MOTOR OPERATED DAMPER SQ, FT; SF SQUARE FEET NOTE SANITARY SOIL VENT - BELOW GRADE ALL GENERAL NOTES, SYMBOL LEGENDS AND DETAILS ARE TO BE CONSIDERED AS APPLICABLE TO ALL PLUMBING AND HAVE APPLICABLE TO ALL PLUMBING AND HAVE AND ABBREVIATIONS SHOWN ON THIS SHEET ARE FOR REFERENCE ONLY AND D NOT INDICATE THEIR INCORPORATION INT THE DESIGN. CONN CONNECT; CONNECTION SUPPLY REGISTER FIRE DAMPER HEAT PUMP WATER SUPPLY SHUT-OFF CONT. CONTINUE; CONTINUATION HIGH PRESSURE CONDENSAT FDC FIRE DEPT CONNECTION MULTI-PURPOSE VALVE VACUUM CLEANING (HOUSE COORD. COORDINATE S.S. STAINLESS STEEL HIGH PRESSURE STEAM FIN FINISH MTD MOUNTED TITLE VACUUM PUMP DISCHARGE CORR CORRIDOR TRENCH DRAIN MTG HIGH-TEMP HOT WATER RETURN FL; FLR FLOOR MOUNTING SANITARY SOIL WASTE - ABOVE FLOOR CR CHEMICAL RESISTING TRANSFER GRILLE FROST/FREEZE PROOF HOT WATER RETURN MUA MAKE UP AIR - -w- - SANITARY SOIL WASTE - BELOW GRADE CT COOLING TOWER TOD TOP OF DUCT FOOTING HOT WATER SUPPLY N C NORMALLY CLOSED CONNECT TO EXISTING SANITARY WET VENT - ABOVE FLOOR CTE FINNED TUBE RADIATION TRAP PRIMER N.O. NORMALLY OPEN - -wv- - SANITARY WET VENT - BELOW GRADE FS FLOW SWITCH TOTAL STATIC PRESSURE CTRLN CENTERLINE PIPING LINETYPE LEGEND ABBREVIATIONS A6 A4 NONE NONE

CHA

49 DARTMOUTH STRE PORTLAND MAINE 04101 207-775-1059

COPYRIGHT CHA Architecture Reuse or reproduction of the ontents of this document is permitted without written ermission of CHA Architect

RENOVATION Hall 0442 , Curtis I Maine 0 Academy, Castine, N HALL Maine Maritime / Pleasant Street,

No. Date Description Revision Schedule

NOT FOR

JOB NO.


100% CONSTRUCTION DOCUMENTS - ISSUED FOR BIDDING

1/22/2023

PLUMBING AND HVAC NOTES, LEGEND AND ABBREVIATIONS

SHEET

|P000

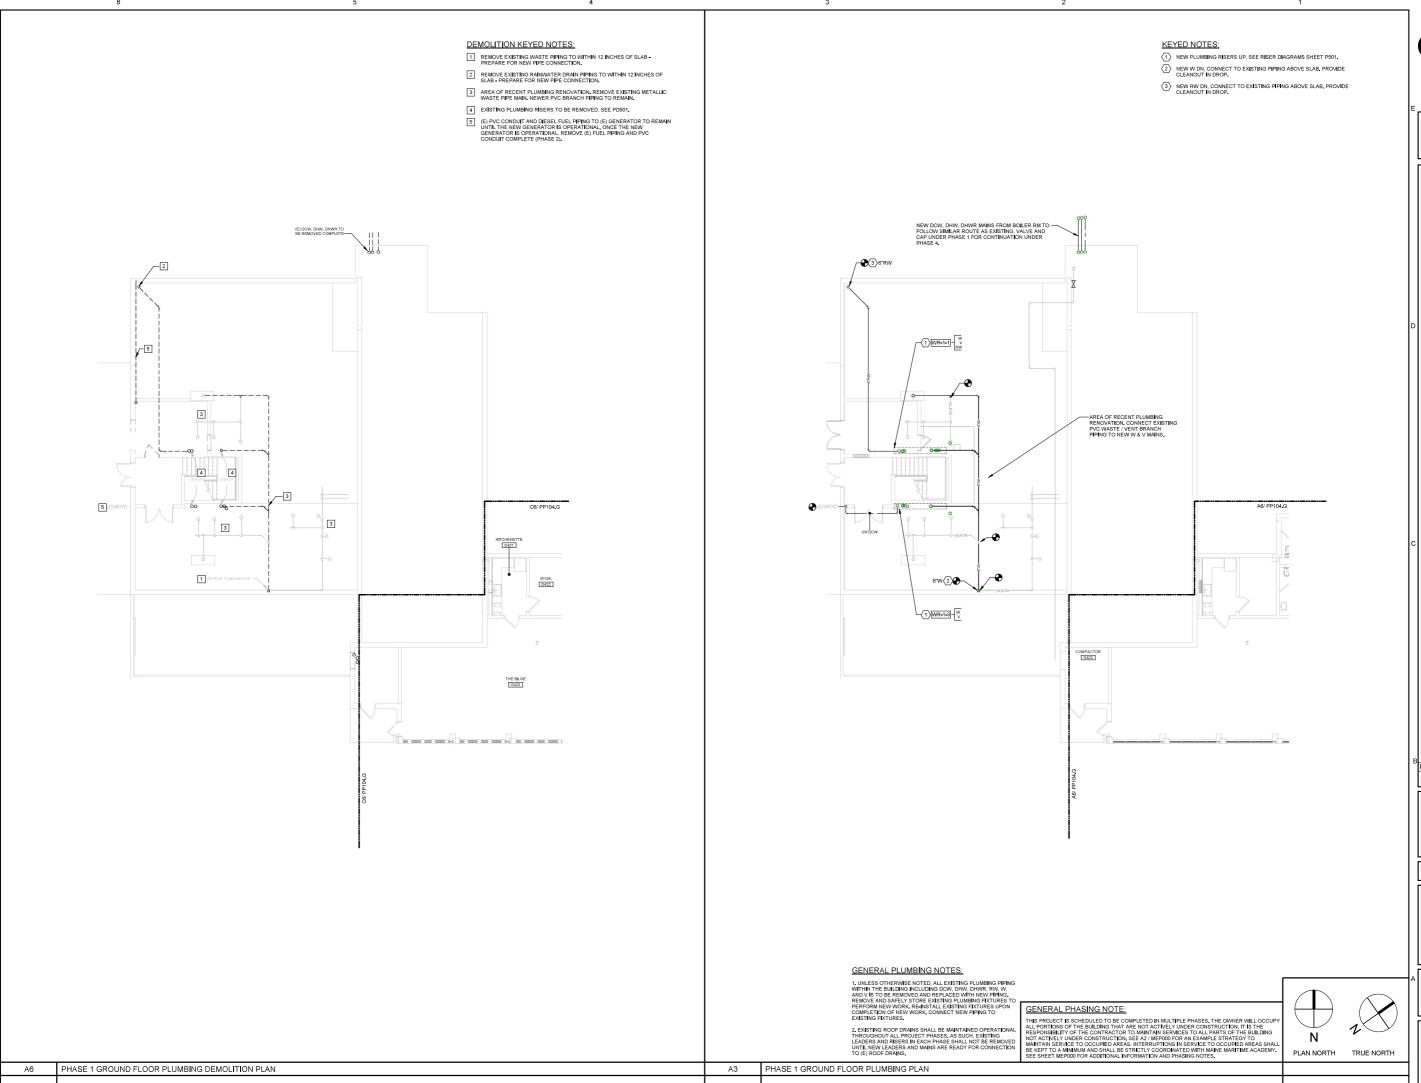

CURTIS HALL RENOVATIONS Maine Maritime Academy, Curtis Hall Pleasant Street, Castine, Maine 04421

QUADRANT KEY PLAN

No. Date Description Revision Schedule

NOT FOR CONSTRUCTION

JOB NO. 076982


ISSUE

100% CONSTRUCTION DOCUMENTS - ISSUED FOR BIDDING 11/22/2023

TITLE

PHASE 1 GROUND
FLOOR PLUMBING
DEMOLITION & NEW
PLANS

P101.G

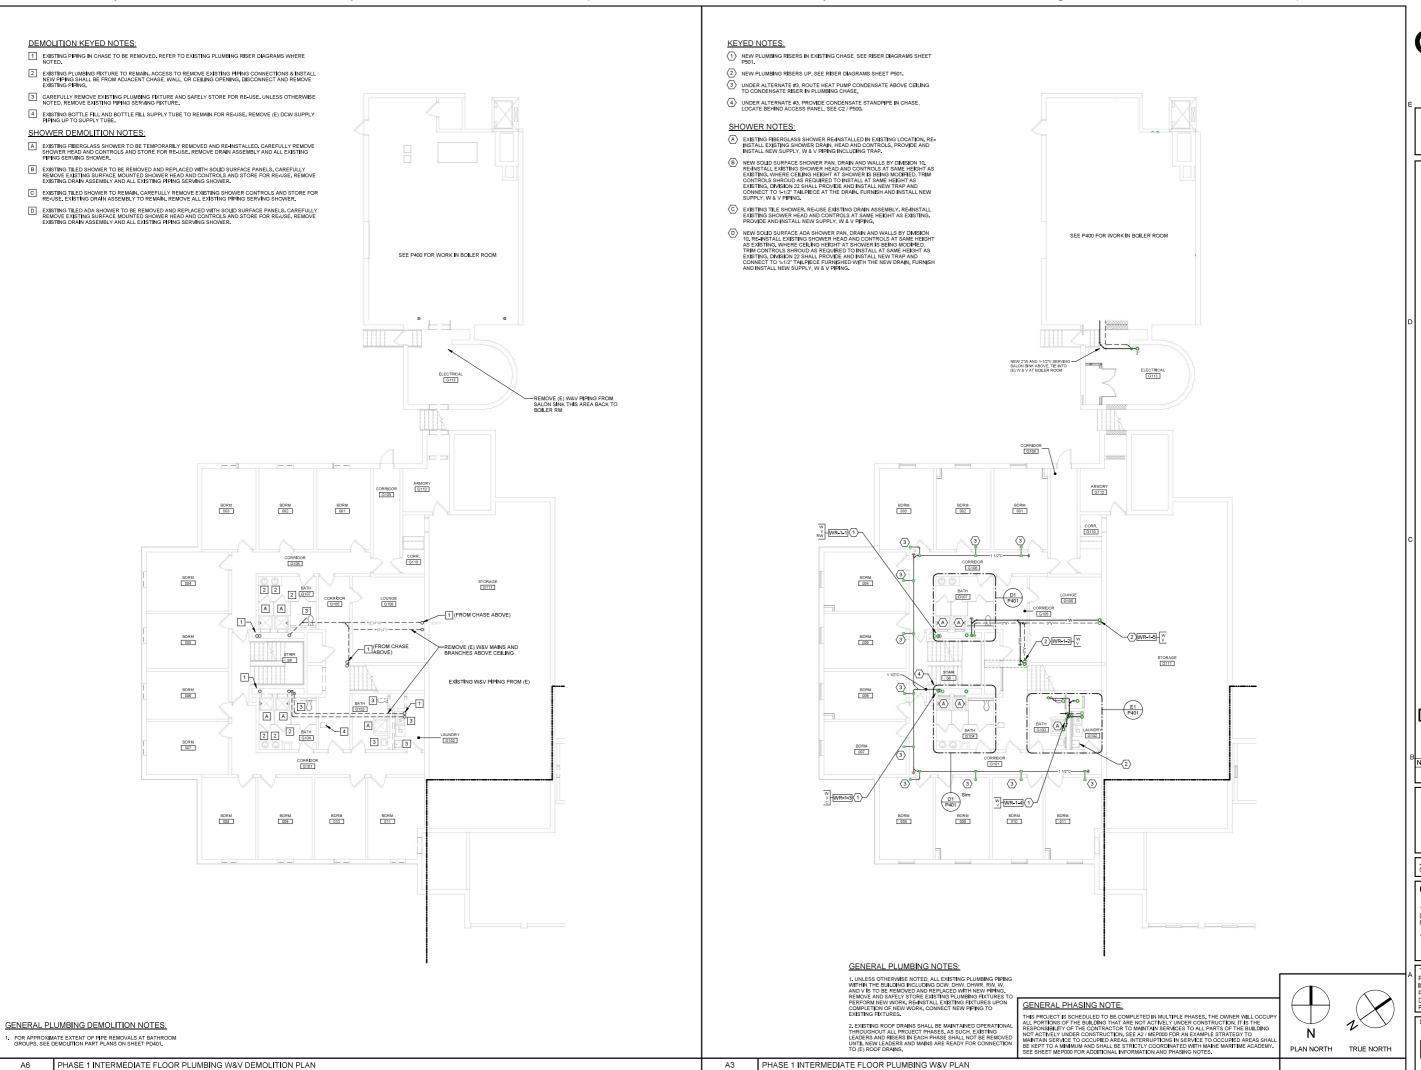

Reuse or reproduction of the ontents of this document is no permitted without written ermission of CHA Architectur

RENOVATIONS Academy, Curtis Hall Castine, Maine 0442

CURTIS HALL Maine Maritime, Pleasant Street,

QUADRANT KEY PLAN

No. Date Description Revision Schedule

> NOT FOR CONSTRUCTION

JOB NO. 076982


ISSUE

100% CONSTRUCTION DOCUMENTS - ISSUED FOR BIDDING

11/22/2023

TITLE PHASE 1 PHASE 1 INTERMEDIATE FLOOR PLUMBING W&V DEMOLITION & NEW PLANS

PL101.0

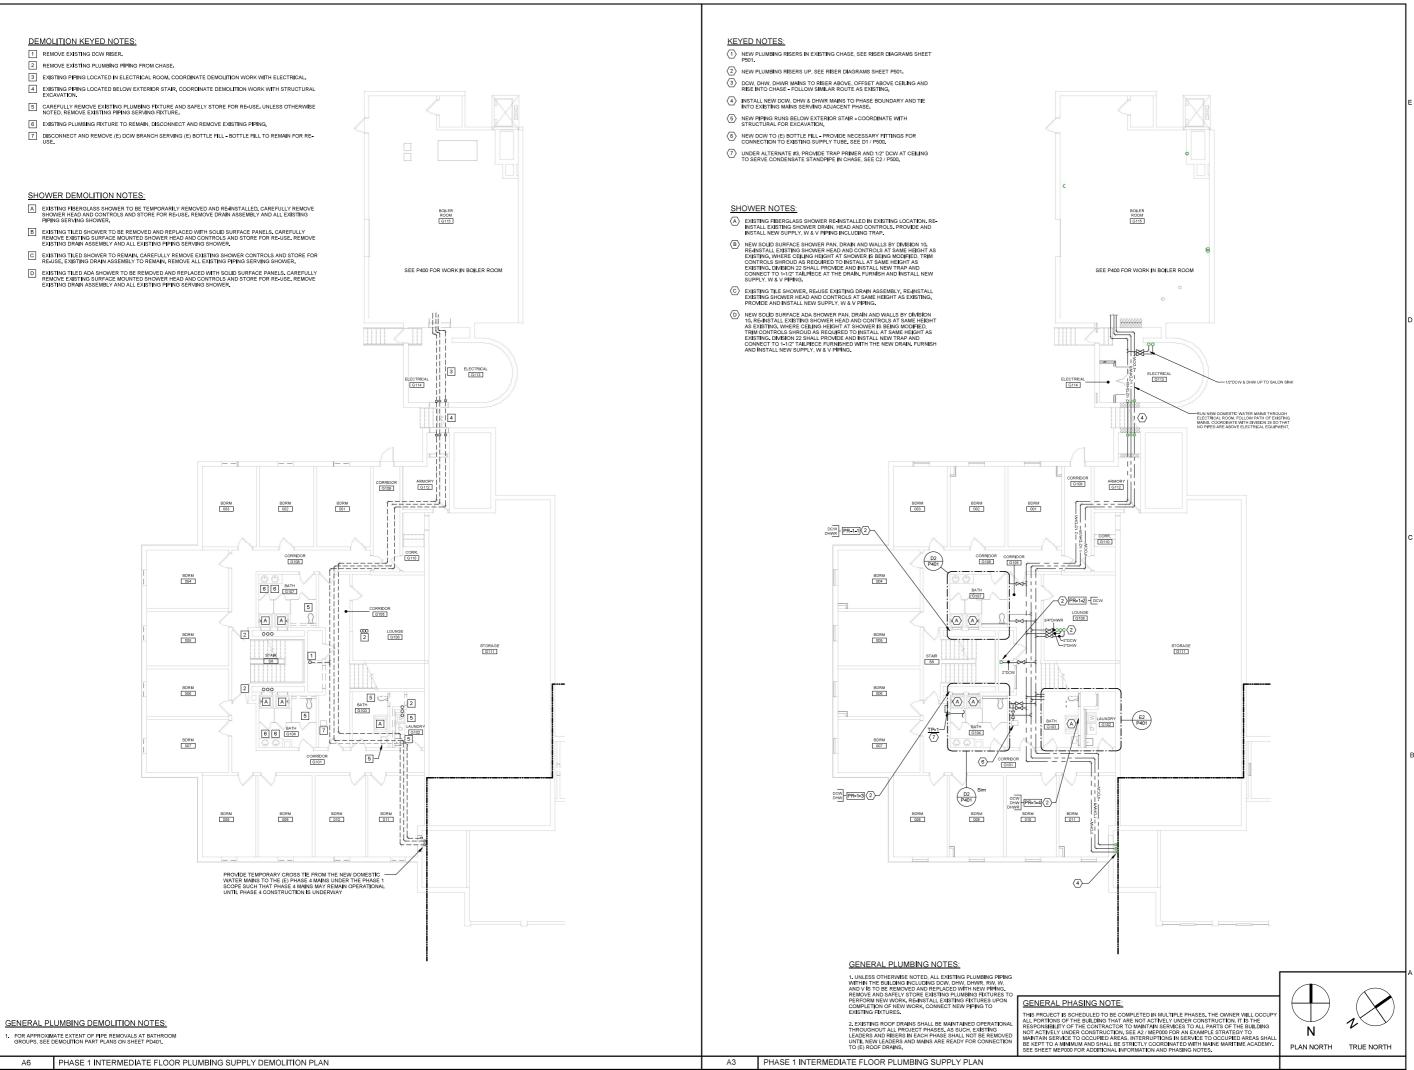

Reuse or reproduction of the ontents of this document is n permitted without written ermission of CHA Architectur

RENOVATIONS Academy, Curtis Hall Castine, Maine 0442

CURTIS HALL Maine Maritime / Pleasant Street,

QUADRANT KEY PLAN No. Date Description

Revision Schedule

NOT FOR

CONSTRUCTION


JOB NO. 076982

ISSUE

100% CONSTRUCTION DOCUMENTS - ISSUED FOR BIDDING 11/22/2023

TITLE PHASE 1 INTERMEDIATE FLOOR PLUMBING SUPPLY DEMOLITION & NEW PLANS

PP101.0

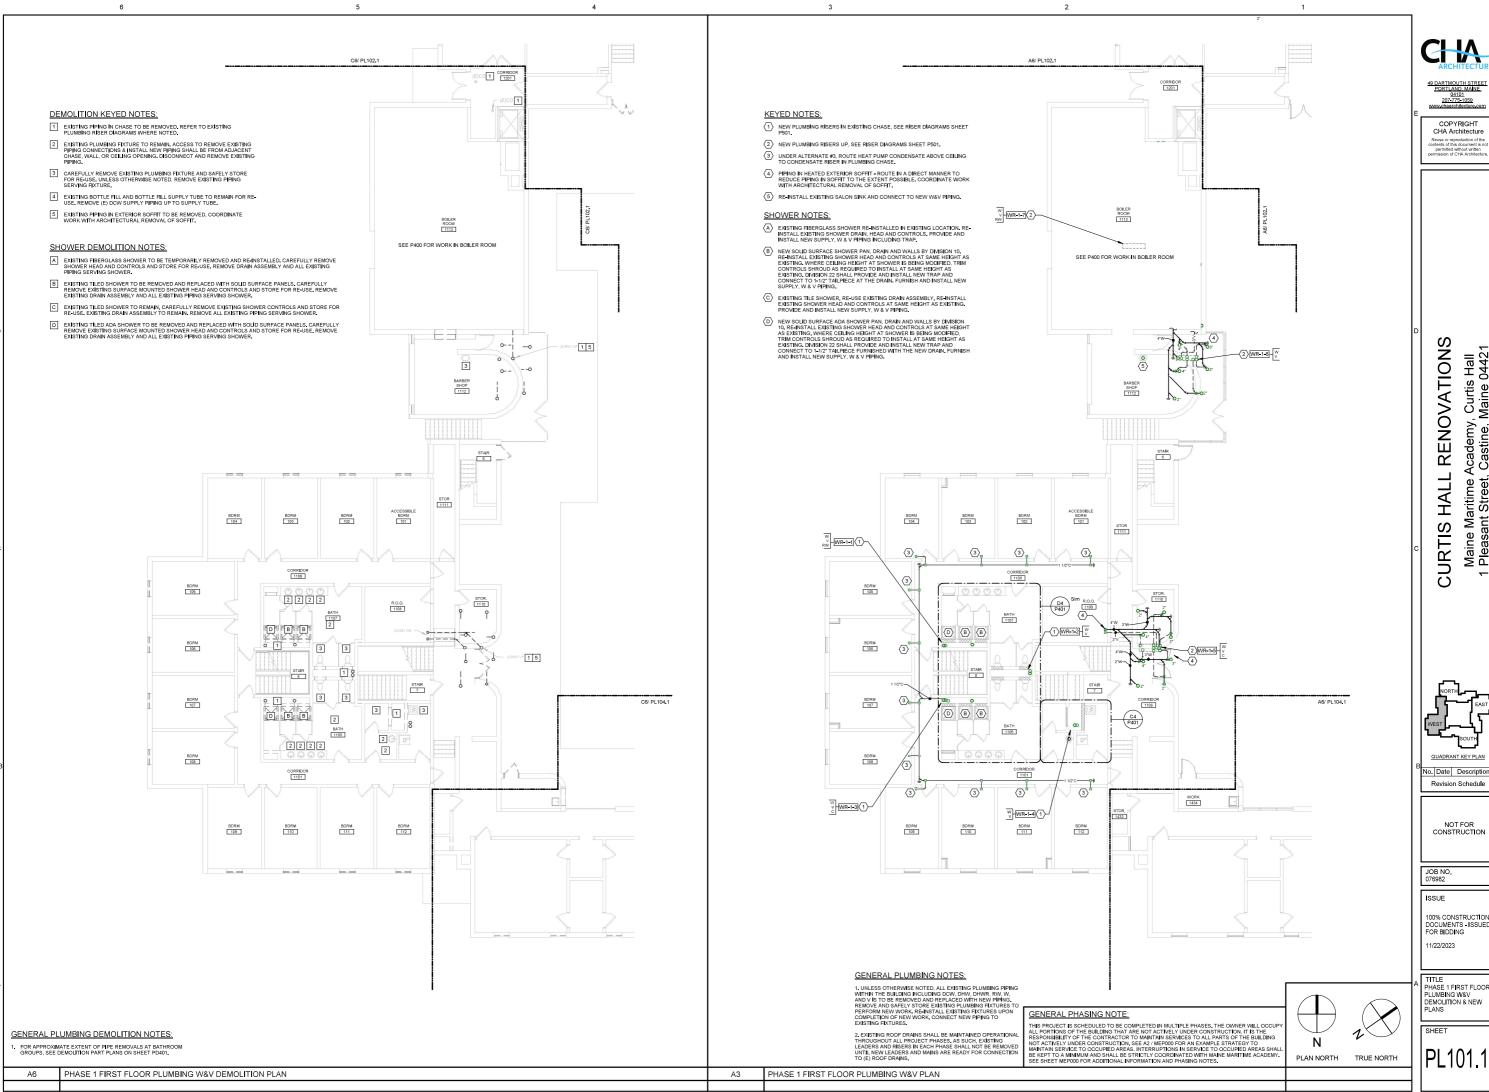

Reuse or reproduction of the ontents of this document is no permitted without written ermission of CHA Architectur

Academy, Curtis Hall Castine, Maine 0442 Maine Maritime A Pleasant Street,


QUADRANT KEY PLAN

NOT FOR

100% CONSTRUCTION DOCUMENTS - ISSUED FOR BIDDING

TITLE
PHASE 1 FIRST FLOOR
PLUMBING W&V
DEMOLITION & NEW
PLANS

PL101.1

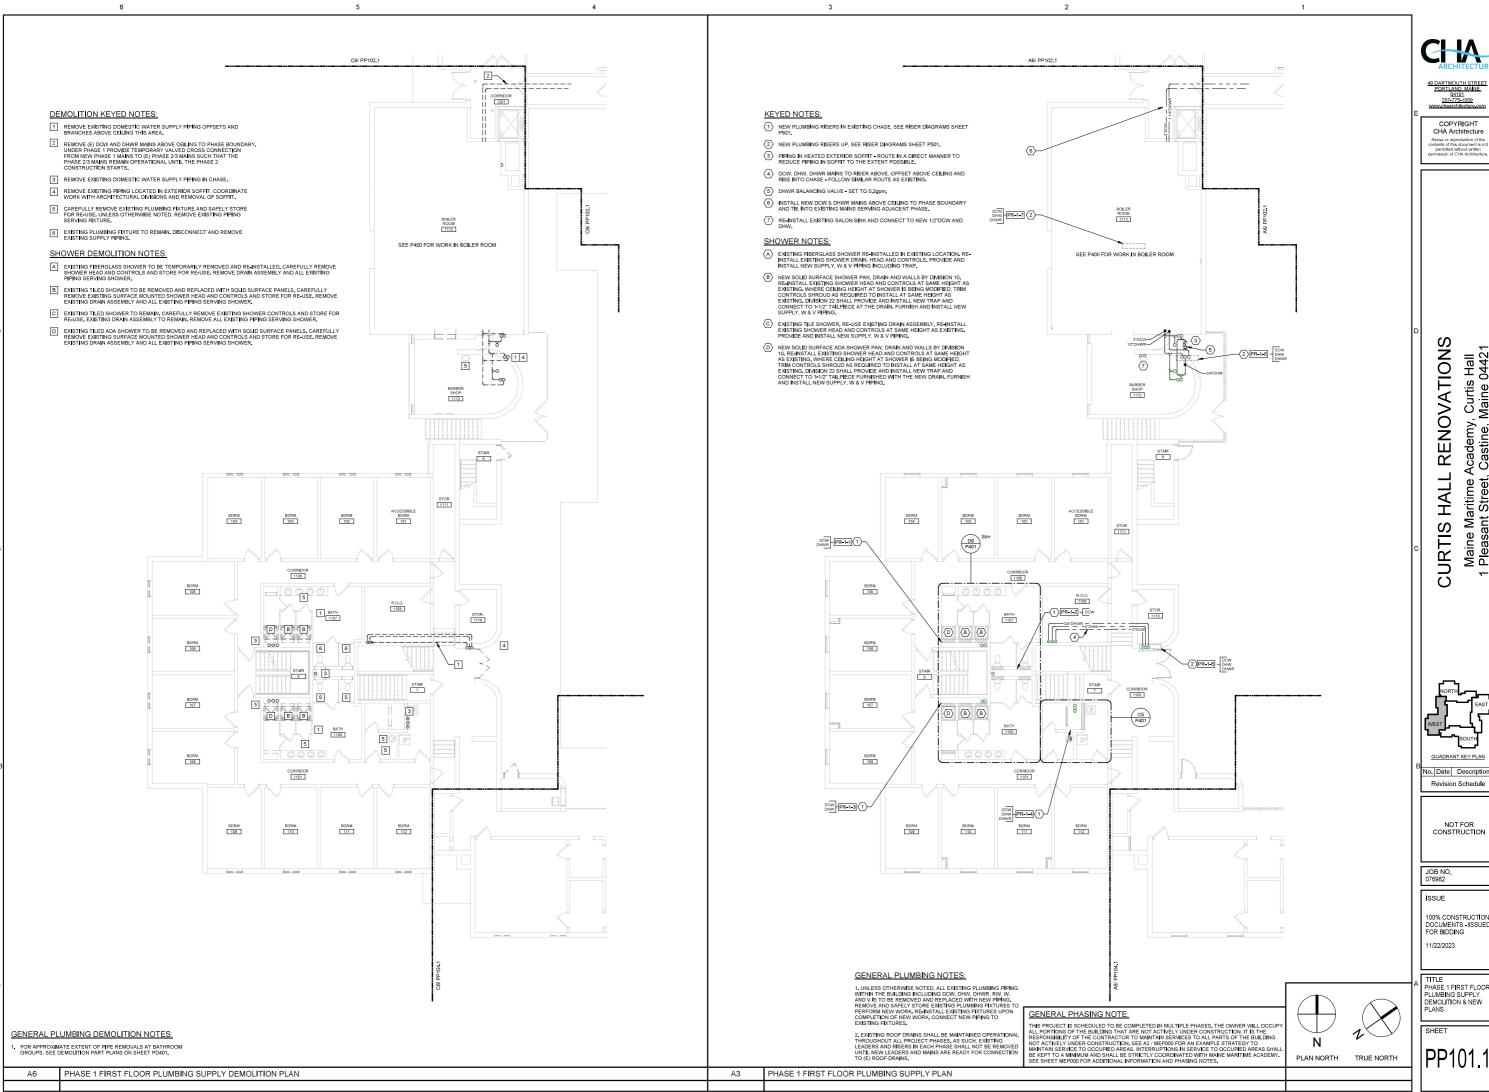

Reuse or reproduction of the ontents of this document is no permitted without written ermission of CHA Architectur

Academy, Curtis Hall Castine, Maine 0442 Maine Maritime A Pleasant Street,


QUADRANT KEY PLAN

NOT FOR CONSTRUCTION

100% CONSTRUCTION DOCUMENTS - ISSUED FOR BIDDING

TITLE
PHASE 1 FIRST FLOOR
PLUMBING SUPPLY
DEMOLITION & NEW
PLANS

PP101.1

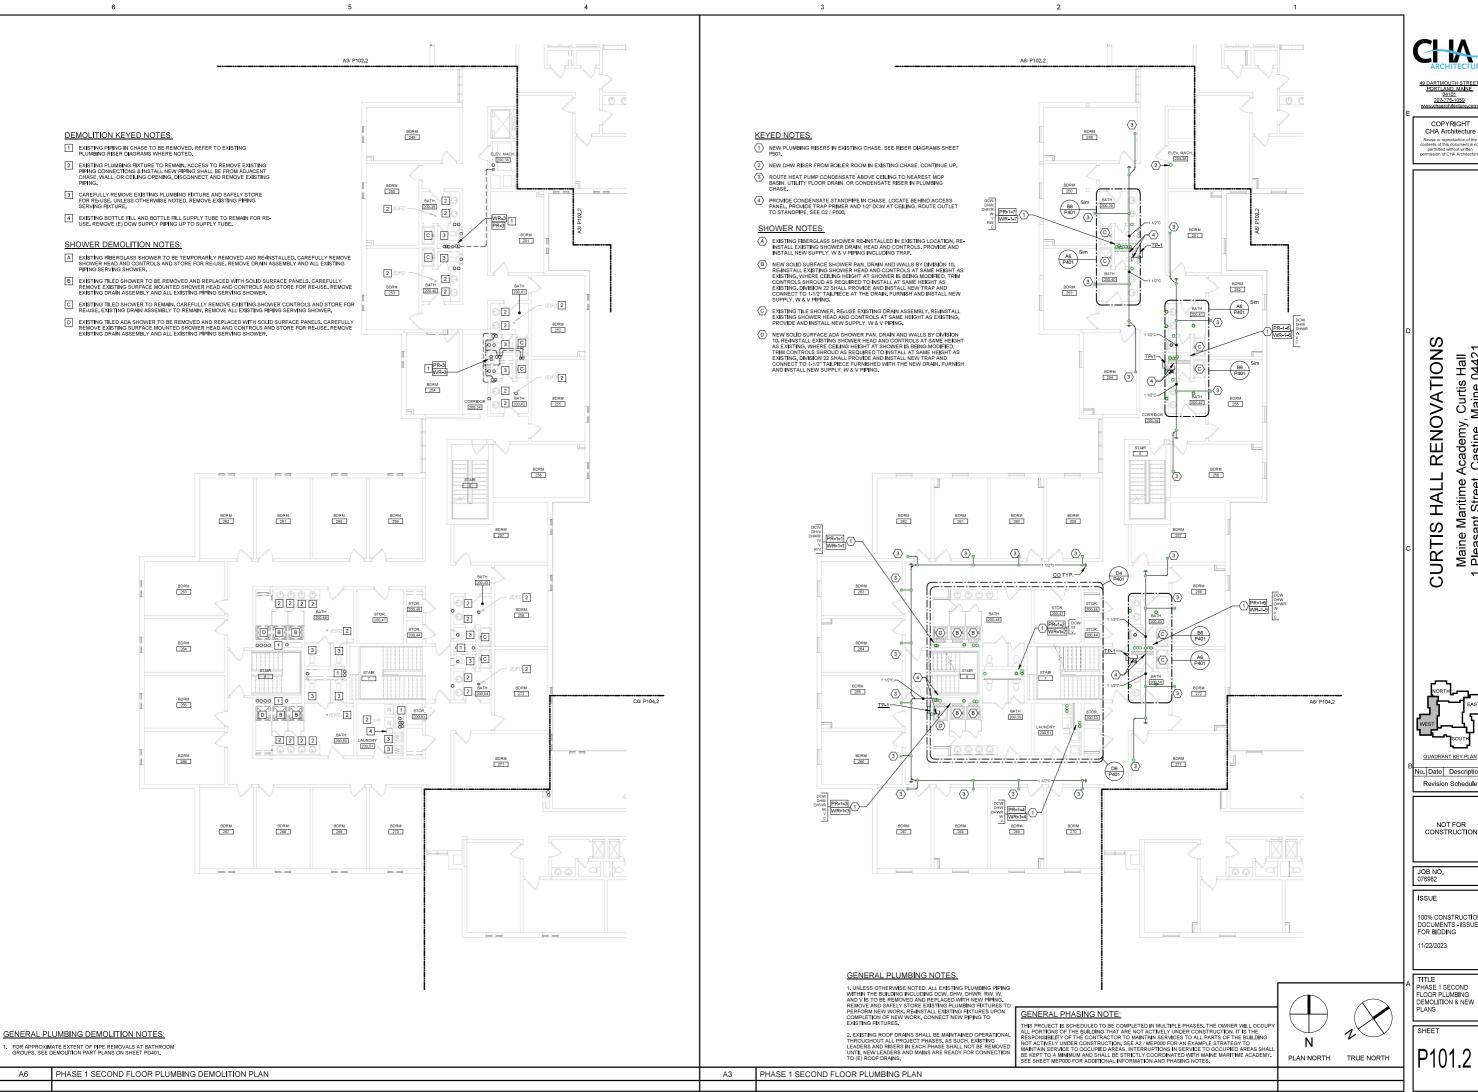

Reuse or reproduction of the ontents of this document is n permitted without written ermission of CHA Architectur

Academy, Curtis Hall , Castine, Maine 0442 Maine Maritime A Pleasant Street,


QUADRANT KEY PLAN No Date Description

NOT FOR

100% CONSTRUCTION DOCUMENTS - ISSUED FOR BIDDING

TITLE
PHASE 1 SECOND
FLOOR PLUMBING
DEMOLITION & NEW
PLANS

P101.2

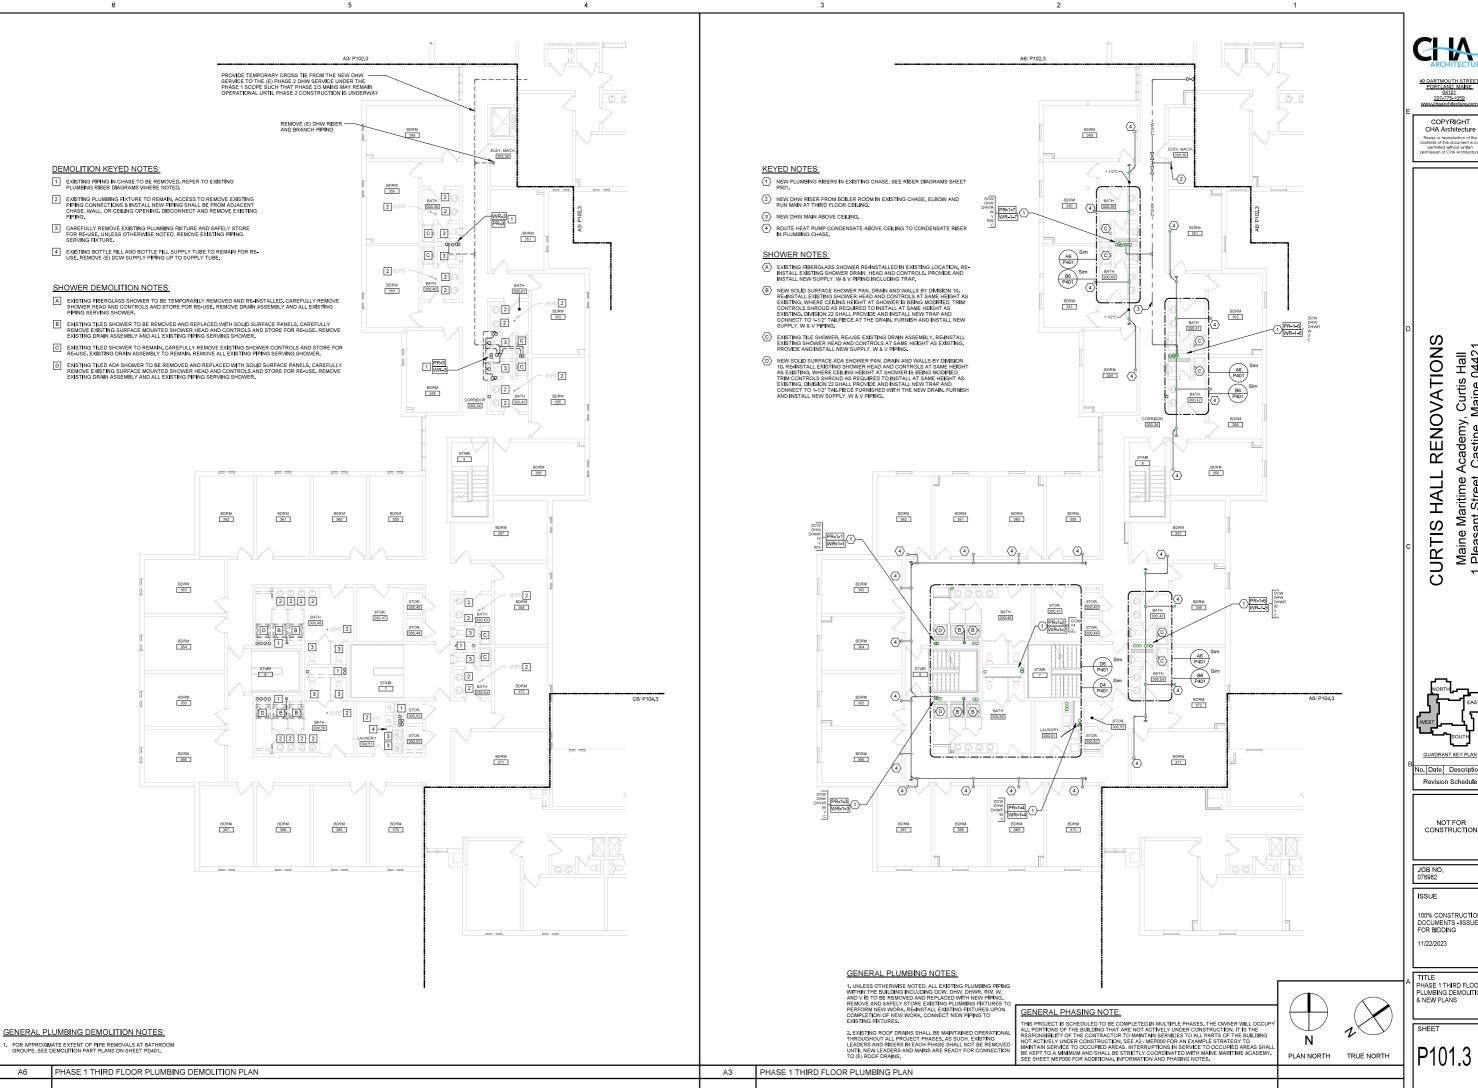

Reuse or reproduction of the ontents of this document is no permitted without written ermission of CHA Architectur

Academy, Curtis Hall Castine, Maine 0442 Maine Maritime A Pleasant Street,


QUADRANT KEY PLAN No Date Description

NOT FOR

100% CONSTRUCTION DOCUMENTS - ISSUED FOR BIDDING

TITLE
PHASE 1 THIRD FLOOR
PLUMBING DEMOLITION
& NEW PLANS

P101.3

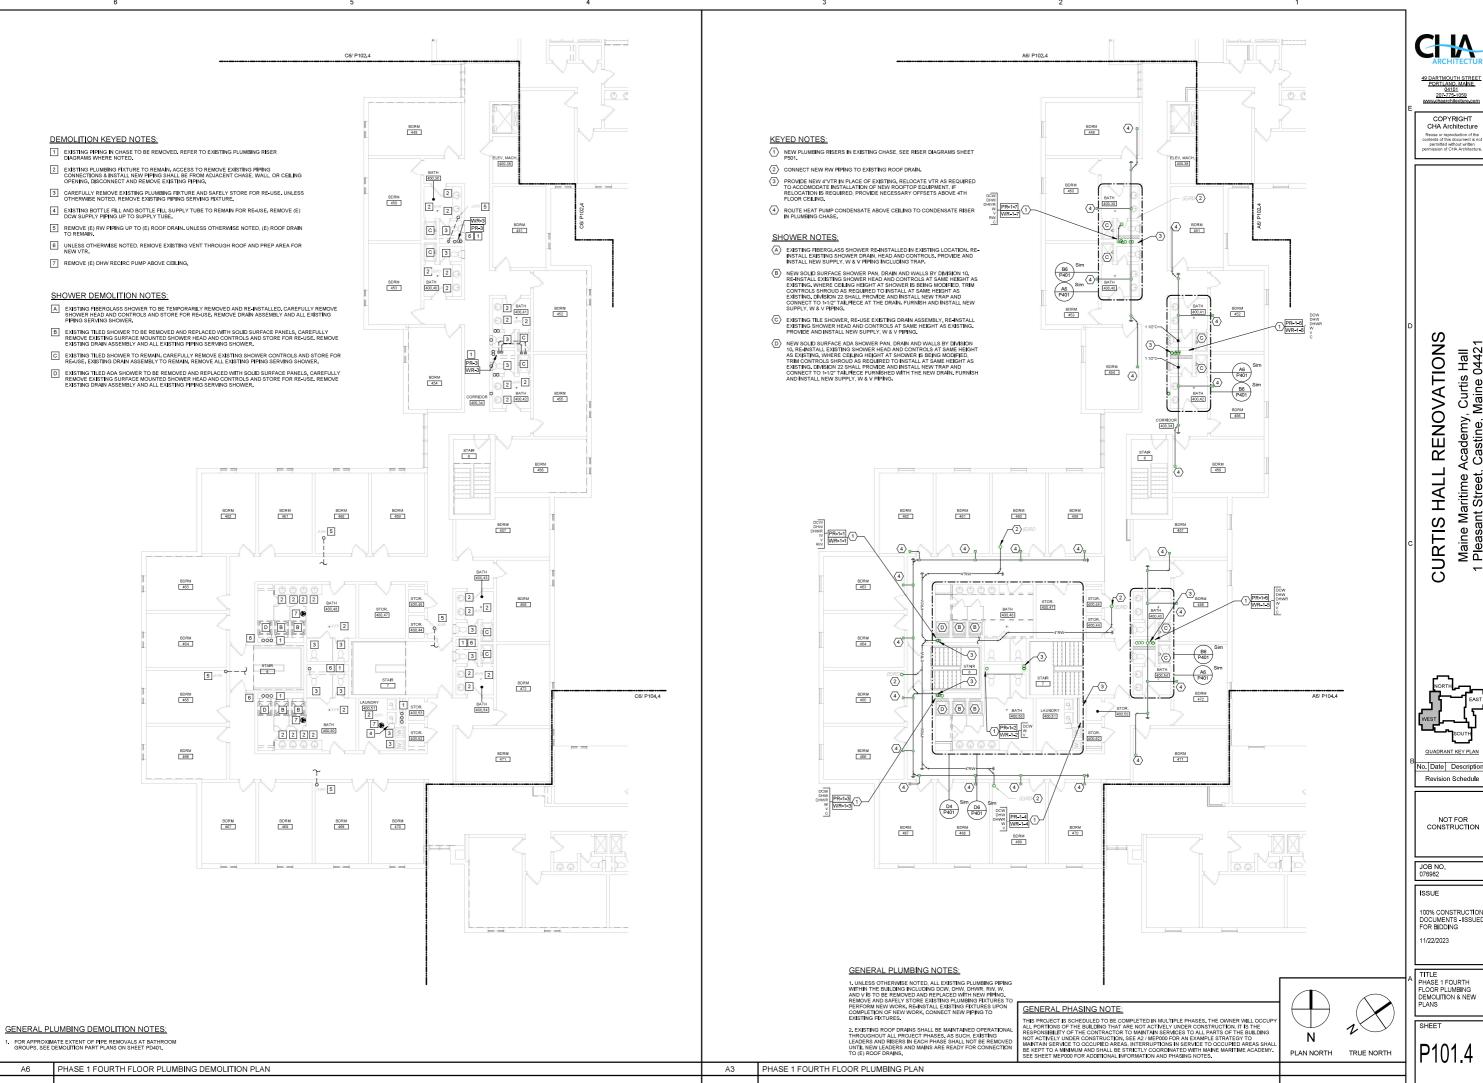

Reuse or reproduction of the ontents of this document is n permitted without written ermission of CHA Architectur

Academy, Curtis Hall Castine, Maine 0442 Maine Maritime A Pleasant Street,


QUADRANT KEY PLAN


NOT FOR

100% CONSTRUCTION DOCUMENTS - ISSUED FOR BIDDING

TITLE
PHASE 1 FOURTH
FLOOR PLUMBING
DEMOLITION & NEW
PLANS

P101.4

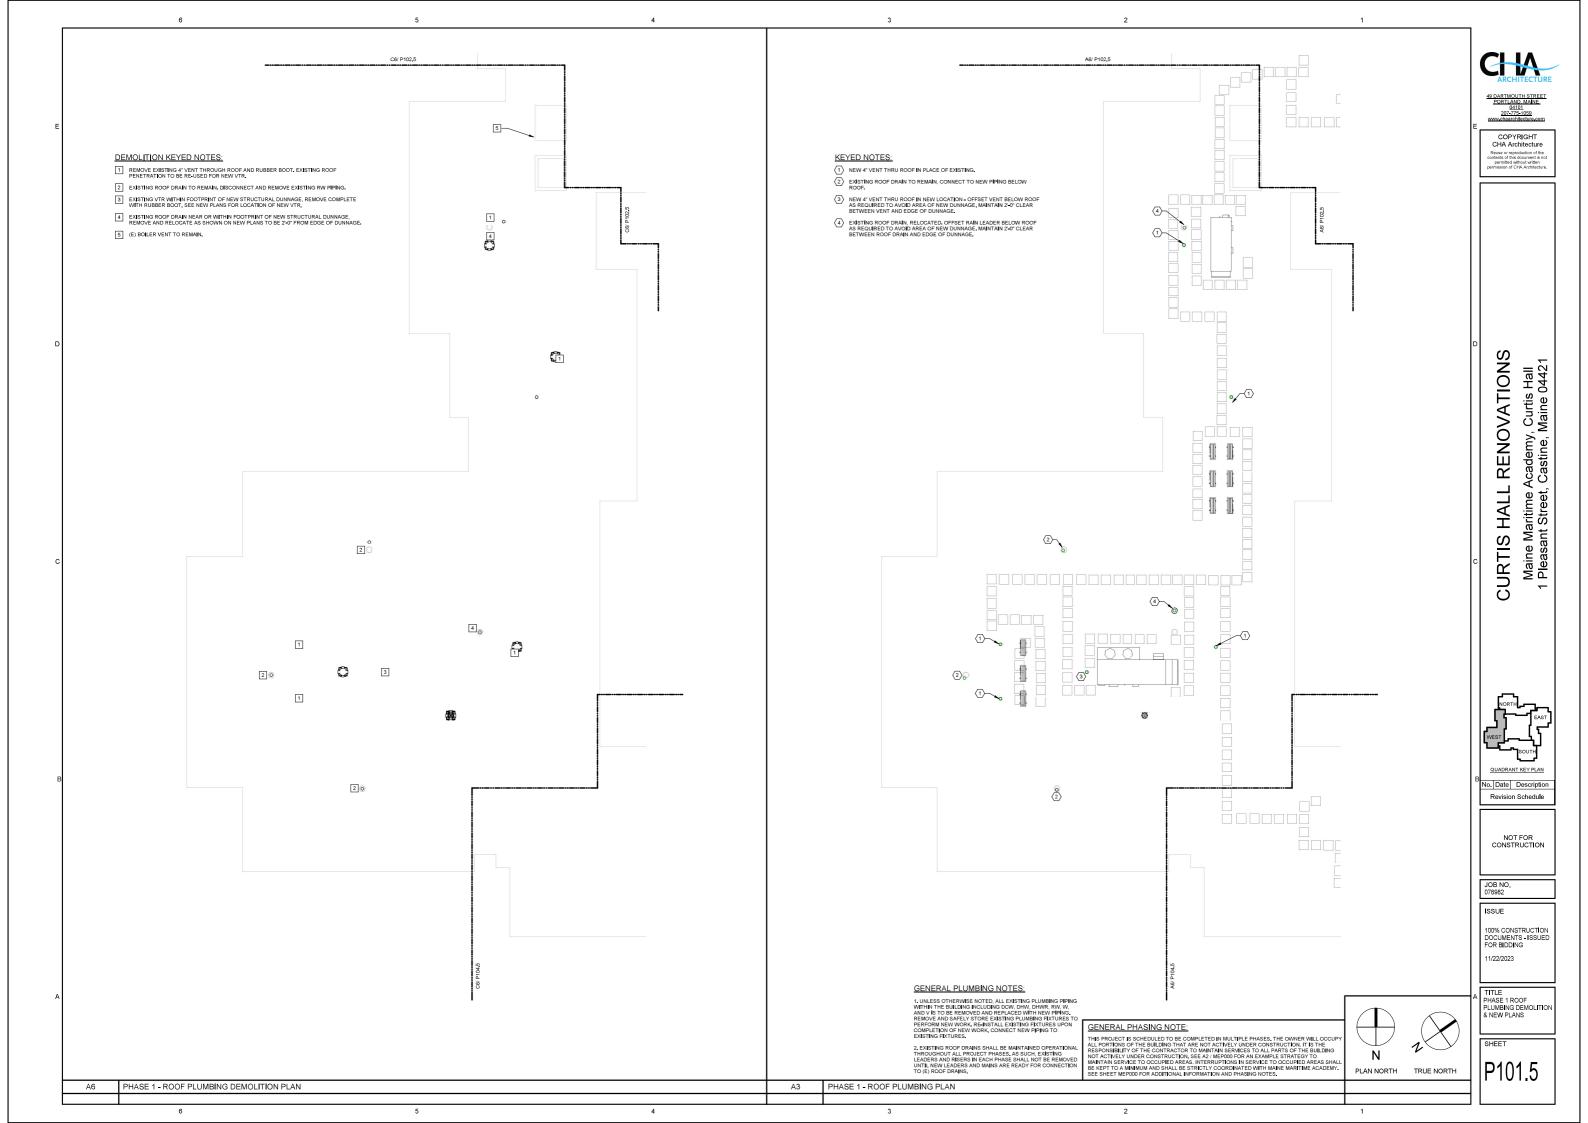

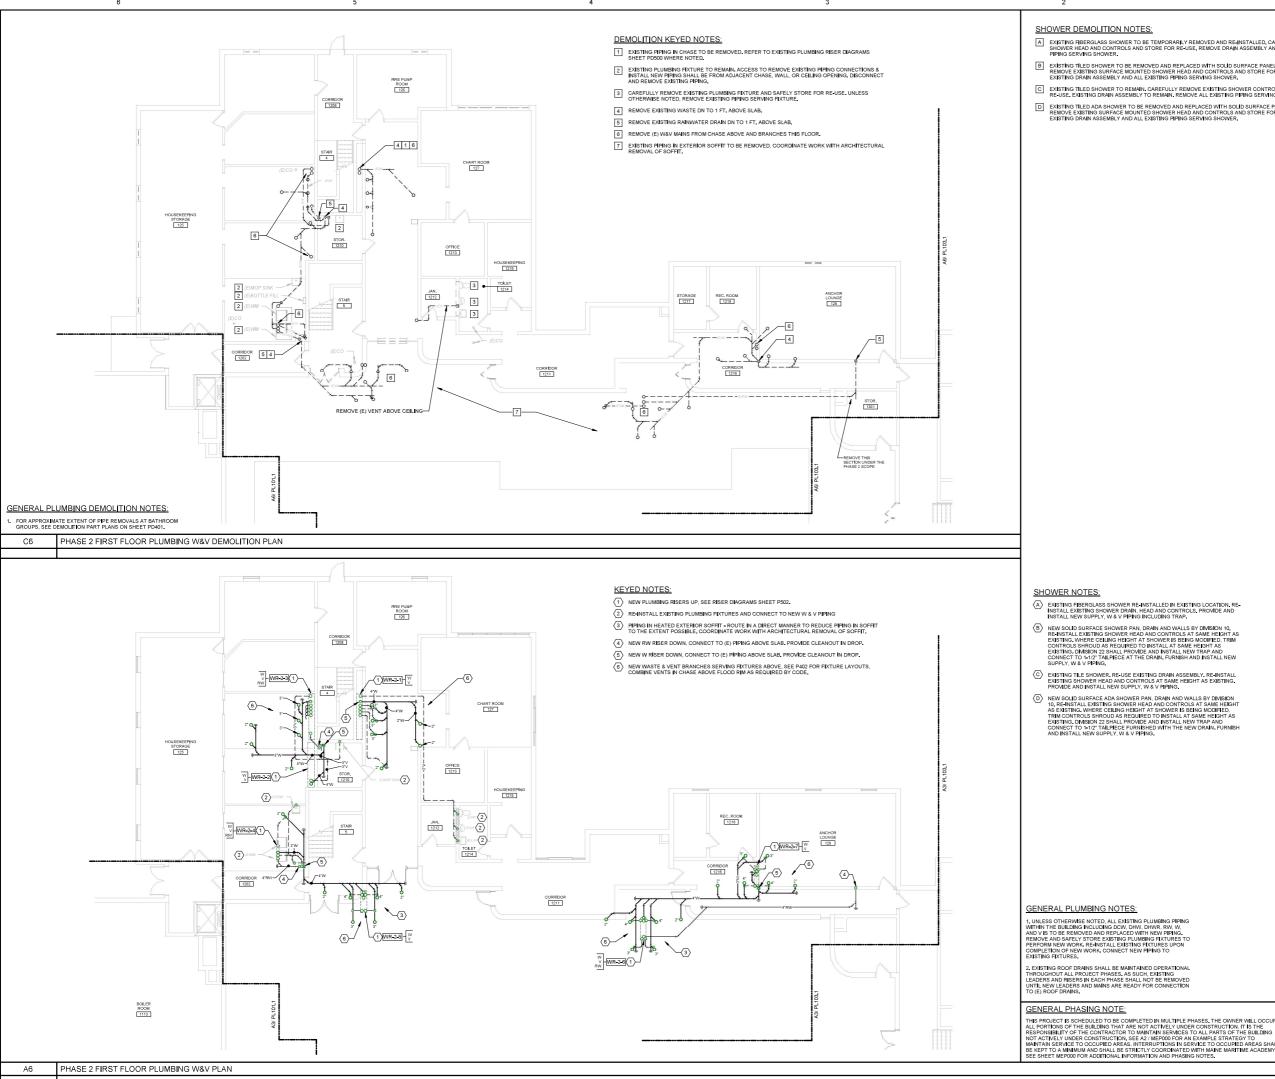

SHOWER DEMOLITION NOTES:

- A EXISTING PIBERGLASS SHOWER TO BE TEMPORARILY REMOVED AND REINSTALLED, CAREFULLY REMOVE SHOWER HEAD AND CONTROLS AND STORE FOR RE-USE, REMOVE DRAIN ASSEMBLY AND ALL EXISTING PIPHOR SERVING SHOWER.
- B EXISTING TILED SHOWER TO BE REMOVED AND REPLACED WITH SOLID SURFACE PANELS, CAREFULLY REMOVE EXISTING SURFACE MOUNTED SHOWER HEAD AND CONTROLS AND STORE FOR RE-USE, REMOVE EXISTING PANN ASSEMBLY AND ALL EXISTING PIENDS SERVING SHOWER.
- © EXISTING TILED SHOWER TO REMAIN. CAREFULLY REMOVE EXISTING SHOWER CONTROLS AND STORE FOR RE-USE. EXISTING DRAIN ASSEMBLY TO REMAIN. REMOVE ALL EXISTING PIPING SERVING SHOWER.
- D EXISTING TILED ADA SHOWER TO BE REMOVED AND REPLACED WITH SOLID SURFACE PANELS, CAREFULLY REMOVE EXISTING SURFACE MOUNTED SHOWER HEAD AND CONTROLS AND STORE FOR RE-USE, REMOVE EXISTING PANN ASSEMBLY AND ALL EXISTING PIRMS ESPRING SHOWED.



COPYRIGHT CHA Architecture

Maine Maritime Academy, Curtis Hall Pleasant Street, Castine, Maine 0442'

CURTIS HALL RENOVATIONS

QUADRANT KEY PLAN

No. Date Description Revision Schedule

NOT FOR

JOB NO. 076982

ISSUE


100% CONSTRUCTION DOCUMENTS - ISSUED FOR BIDDING 1/22/2023

TITLE
PHASE 2 FIRST FLOOR
PLUMBING W&V
DEMOLITION & NEW
PLANS

PL102.1

Ν

PLAN NORTH

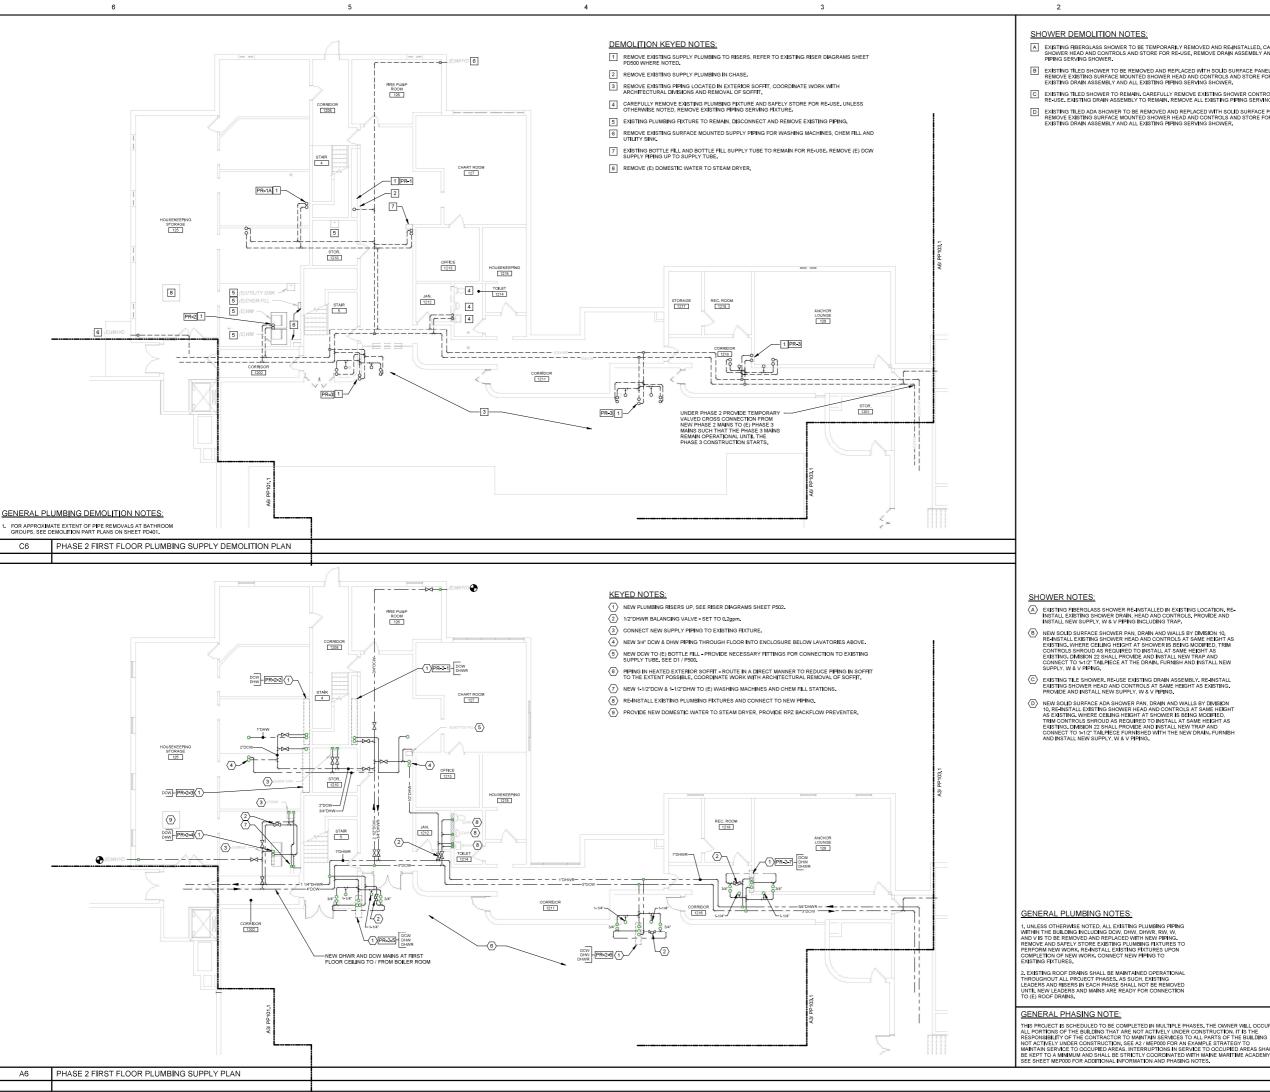

- A EXISTING FIBERGLASS SHOWER TO BE TEMPORARILY REMOVED AND REINSTALLED, CAREFULLY REMOVE SHOWER HEAD AND CONTROLS AND STORE FOR RE-USE, REMOVE DRAIN ASSEMBLY AND ALL EXISTING PIPMS SERVING SHOWER.
- B EXISTING TILED SHOWER TO BE REMOVED AND REPLACED WITH SOLID SURFACE PANELS, CAREFULLY REMOVE EXISTING SURFACE MOUNTED SHOWER HEAD AND CONTROLS AND STORE FOR RE-USE, REMOVE EXISTING PANIA ASSEMBLY AND ALL EXISTING PIENTS
- © EXISTING TILED SHOWER TO REMAIN. CAREFULLY REMOVE EXISTING SHOWER CONTROLS AND STORE FOR RE-USE. EXISTING DRAIN ASSEMBLY TO REMAIN. REMOVE ALL EXISTING PIPING SERVING SHOWER.
- D EXISTING TILED ADA SHOWER TO BE REMOVED AND REPLACED WITH SOLID SURFACE PANELS, CAREFULLY REMOVE EXISTING SURFACE MOUNTED SHOWER HEAD AND CONTROLS AND STORE FOR RE-USE, REMOVE EXISTING PANN ASSEMBLY AND ALL EXISTING PI



RENOVATIONS

Academy, Curtis Hall Castine, Maine 0442 **CURTIS HALL** Maine Maritime, Pleasant Street,



QUADRANT KEY PLAN

No. Date Description Revision Schedule

NOT FOR

JOB NO. 076982

ISSUE

100% CONSTRUCTION DOCUMENTS - ISSUED FOR BIDDING

1/22/2023


TITLE
PHASE 2 FIRST FLOOR
PLUMBING SUPPLY
DEMOLITION & NEW
PLANS

Ν

PLAN NORTH

TRUE NORTH

PP102.1

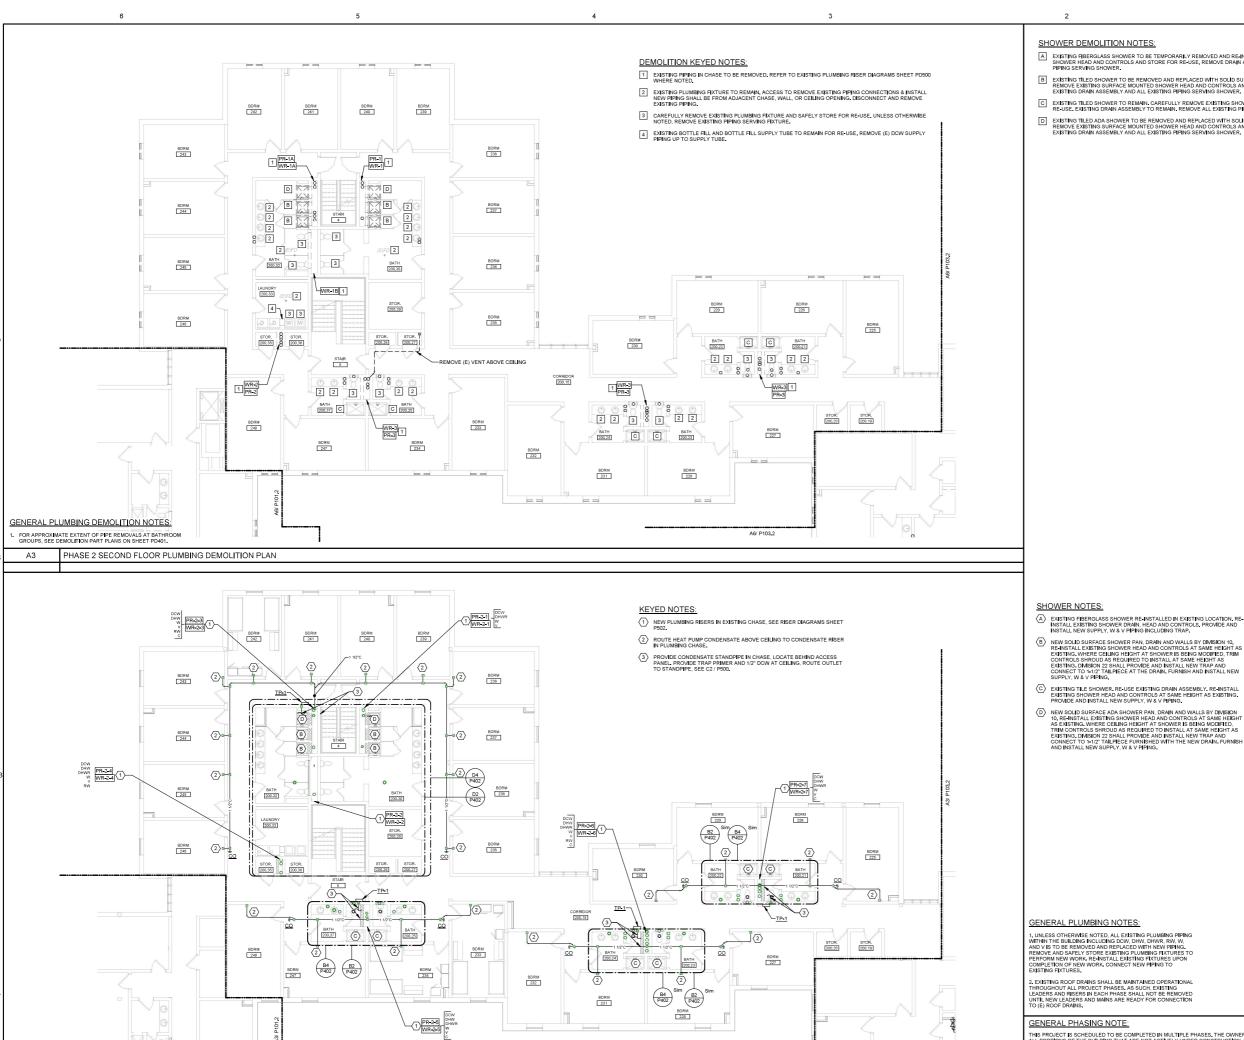

PHASE 2 SECOND FLOOR PLUMBING PLAN

SHOWER DEMOLITION NOTES:

- A EXISTING FIBERGLASS SHOWER TO BE TEMPORARILY REMOVED AND RE-INSTALLED, CAREFULLY REMOVE SHOWER HEAD AND CONTROLS AND STORE FOR RE-USE, REMOVE DRAIN ASSEMBLY AND ALL EXISTING PIPHOS SERVING SHOWER.
- B EXISTING TILED SHOWER TO BE REMOVED AND REPLACED WITH SOLID SURFACE PANELS, CAREFULLY REMOVE EXISTING SURFACE MOUNTED SHOWER HEAD AND CONTROLS AND STORE FOR RE-LYSE, REMOVE EXISTING DRAIN ASSEMBLY AND ALL EXISTING PHING SERVINGS SHOWER.
- © EXISTING TILED SHOWER TO REMAIN. CAREFULLY REMOVE EXISTING SHOWER CONTROLS AND STORE FOR RE-USE. EXISTING DRAIN ASSEMBLY TO REMAIN. REMOVE ALL EXISTING PIPING SERVING SHOWER.
- D EXISTING TILED ADA SHOWER TO BE REMOVED AND REPLACED WITH SOLID SURFACE PANELS, CAREFULLY REMOVE EXISTING SURFACE MOUNTED SHOWER HEAD AND CONTROLS AND STORE FOR RE-USE, REMOVE EXISTING DRAIN ASSEMBLY AND ALL EXISTING PRINOS SHOWER.



COPYRIGHT CHA Architecture

Reuse or reproduction of the ontents of this document is n permitted without written ermission of CHA Architectur

RENOVATIONS Academy, Curtis Hall Castine, Maine 0442

CURTIS HALL Maine Maritime, Pleasant Street,

QUADRANT KEY PLAN

No. Date Description Revision Schedule

NOT FOR

JOB NO. 076982

ISSUE

100% CONSTRUCTION DOCUMENTS - ISSUED FOR BIDDING

1/22/2023


TITLE
PHASE 2 SECOND
FLOOR PLUMBING
DEMOLITION & NEW
PLANS

P102.2

THIS PROJECT IS SCHEDULED TO BE COMPLETED IN MULTIPLE PHASES, THE OWNER WILL OCCUP ALL PORTRONS OF THE BUILDING THAT ARE NOT ACTIVILY UNDER CONSTRUCTION. IT IS THE RESPONSIBILITY OF THE CONTRACTOR TO MANTAIN SERVICES TO ALL PARTS OF THE BUILDING AND ADDRESS OF THE STATE OF THE STATE OF THE STATE OF THE STATE OF THE BUILDING MAINTAIN SERVICE TO OCCUPIED AREAS, INTERVITORIS IN SERVICE TO OCCUPIED AREAS SHAIL BE REPT TO A MINIMUM AND SHALL BE STRETTY COORDINATED WITH MAINE MARITIME ACADEMY SEE CHEET MEROOP OFFO ADDITIONAL INFORMATION AND PHASING NOTES.

Ν

PLAN NORTH

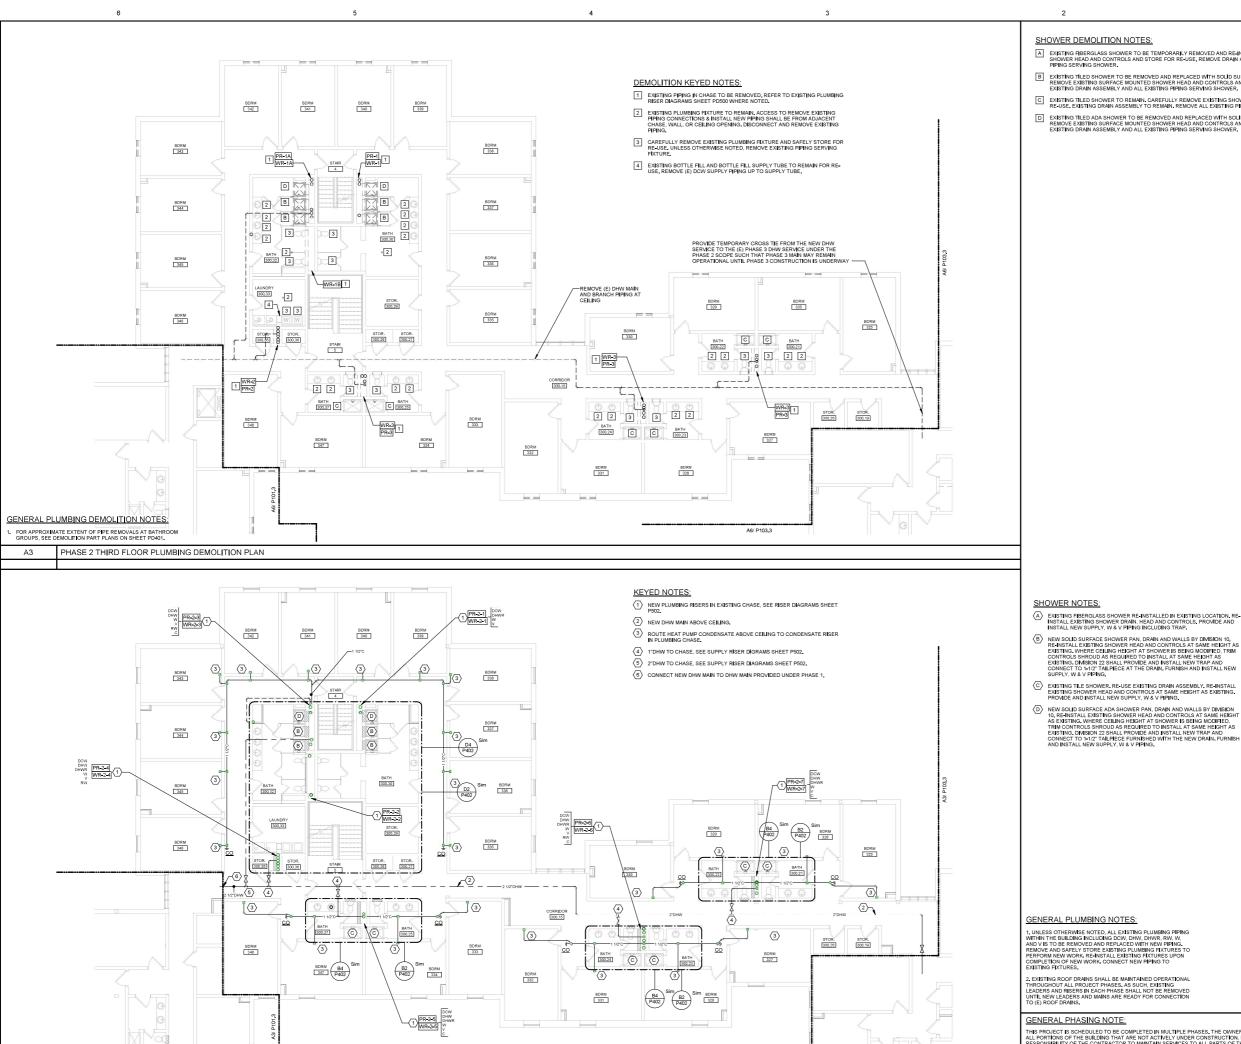

PHASE 2 THIRD FLOOR PLUMBING PLAN

SHOWER DEMOLITION NOTES:

- A EXISTING PIBERGLASS SHOWER TO BE TEMPORARILY REMOVED AND REINSTALLED, CAREFULLY REMOVE SHOWER HEAD AND CONTROLS AND STORE FOR RE-USE, REMOVE DRAIN ASSEMBLY AND ALL EXISTING PIPHOR SERVING SHOWER.
- B EXISTING TILED SHOWER TO BE REMOVED AND REPLACED WITH SOLID SURFACE PANELS, CAREFULLY REMOVE EXISTING SURFACE MOUNTED SHOWER HEAD AND CONTROLS AND STORE FOR RE-LYSE, REMOVE EXISTING DRAIN ASSEMBLY AND ALL EXISTING PHING SERVINGS SHOWER.
- © EXISTING TILED SHOWER TO REMAIN, CAREFULLY REMOVE EXISTING SHOWER CONTROLS AND STORE FOR RE-USE, EXISTING DRAIN ASSEMBLY TO REMAIN, REMOVE ALL EXISTING PIPING SERVING SHOWER.
- D EXISTING TILED ADA SHOWER TO BE REMOVED AND REPLACED WITH SOLID SURFACE PANELS, CAREFULLY REMOVE EXISTING SURFACE MOUNTED SHOWER HEAD AND CONTROLS AND STORE FOR RE-USE, REMOVE EXISTING PANN ASSEMBLY AND ALL EXISTING PI



COPYRIGHT CHA Architecture

Reuse or reproduction of the contents of this document is n permitted without written permission of CHA Architectur

RENOVATIONS Academy, Curtis Hall Castine, Maine 0442

CURTIS HALL Maine Maritime, Pleasant Street,

QUADRANT KEY PLAN

No. Date Description Revision Schedule

> NOT FOR CONSTRUCTION

JOB NO. 076982

ISSUE

100% CONSTRUCTION DOCUMENTS - ISSUED FOR BIDDING 1/22/2023


TITLE
PHASE 2 THIRD FLOOR
PLUMBING DEMOLITION
& NEW PLANS

SHEET

P102.3

THIS PROJECT IS SCHEDULED TO BE COMPLETED IN MULTIPLE PHASES, THE OWNER WILL OCCUP ALL PORTRONS OF THE BUILDING THAT ARE NOT ACTIVILY UNDER CONSTRUCTION. IT IS THE RESPONSIBILITY OF THE CONTRACTOR TO MANTAIN SERVICES TO ALL PARTS OF THE BUILDING AND ADDRESS OF THE STATE OF THE STATE OF THE STATE OF THE STATE OF THE BUILDING MAINTAIN SERVICE TO OCCUPIED AREAS, INTERVITORIS IN SERVICE TO OCCUPIED AREAS SHAIL BE REPT TO A MINIMUM AND SHALL BE STRETTY COORDINATED WITH MAINE MARITIME ACADEMY SEE CHEET MEROOP OFFO ADDITIONAL INFORMATION AND PHASING NOTES.

Ν PLAN NORTH

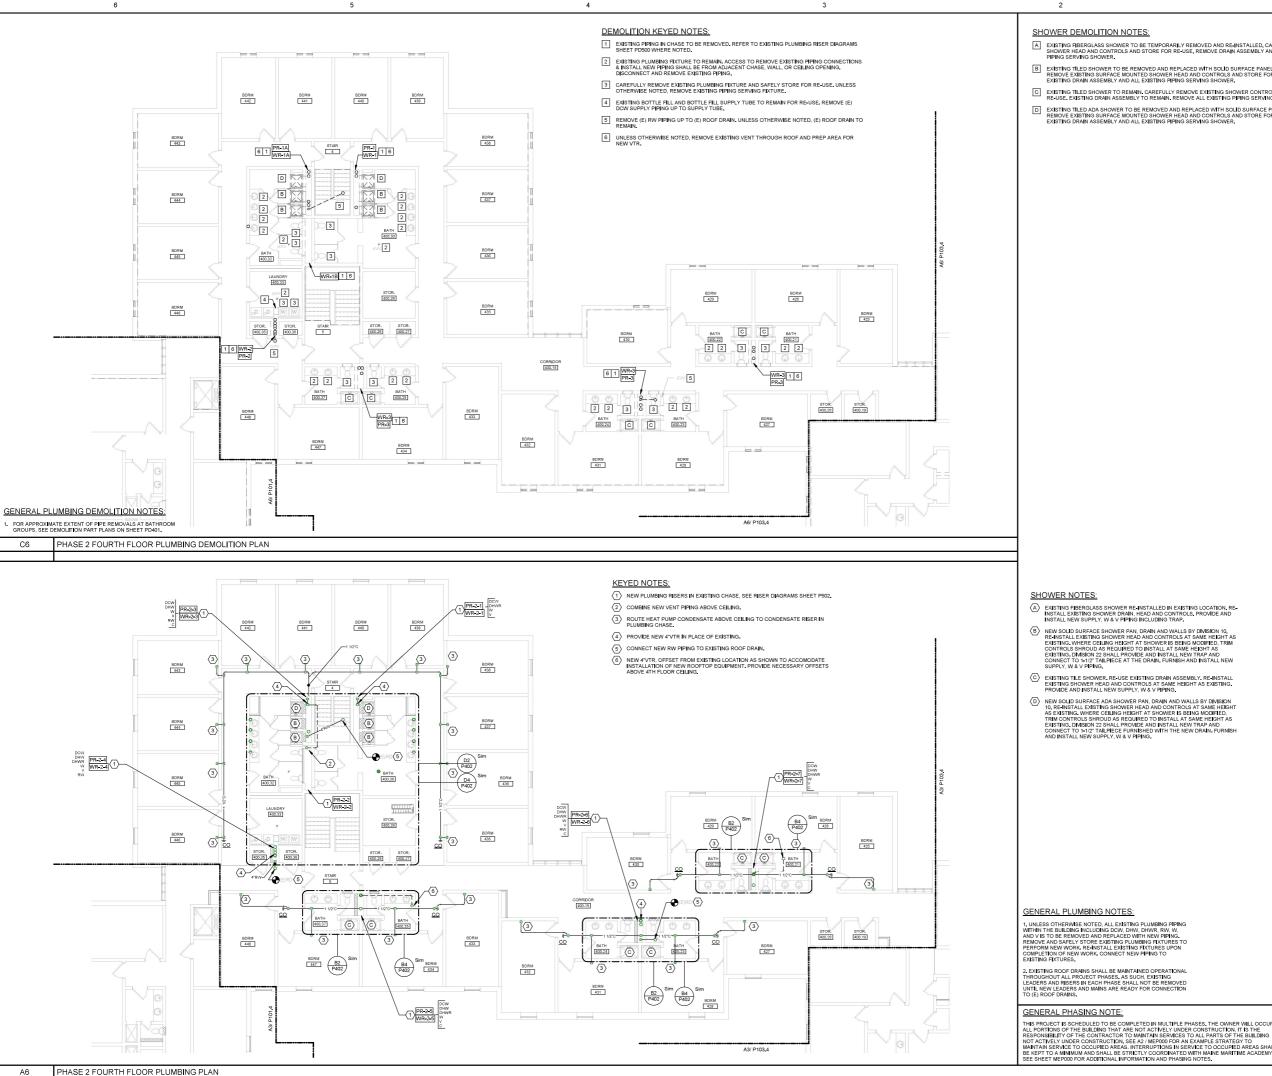

SHOWER DEMOLITION NOTES:

- A EXISTING FIBERGLASS SHOWER TO BE TEMPORARILY REMOVED AND RE-INSTALLED, CAREFULLY REMOVE SHOWER HEAD AND CONTROLS AND STORE FOR RE-USE, REMOVE DRAIN ASSEMBLY AND ALL EXISTING PIPHOS SERVING SHOWER.
- B EXISTING TILED SHOWER TO BE REMOVED AND REPLACED WITH SOLID SURFACE PANELS, CAREFULLY REMOVE EXISTING SURFACE MOUNTED SHOWER HEAD AND CONTROLS AND STORE FOR RE-LYSE, REMOVE EXISTING DRAIN ASSEMBLY AND ALL EXISTING PHING SERVINGS SHOWER.
- © EXISTING TILED SHOWER TO REMAIN. CAREFULLY REMOVE EXISTING SHOWER CONTROLS AND STORE FOR RE-USE. EXISTING DRAIN ASSEMBLY TO REMAIN. REMOVE ALL EXISTING PIPING SERVING SHOWER.
- D EXISTING TILED ADA SHOWER TO BE REMOVED AND REPLACED WITH SOLID SURFACE PANELS, CAREFULLY REMOVE EXISTING SURFACE MOUNTED SHOWER HEAD AND CONTROLS AND STORE FOR RE-USE, REMOVE EXISTING PANN ASSEMBLY AND ALL EXISTING PI

COPYRIGHT CHA Architecture

Reuse or reproduction of the ontents of this document is n permitted without written ermission of CHA Architectur

RENOVATIONS

Academy, Curtis Hall Castine, Maine 0442 **CURTIS HALL** Maine Maritime, Pleasant Street,

QUADRANT KEY PLAN

No. Date Description Revision Schedule

NOT FOR

JOB NO. 076982

ISSUE

100% CONSTRUCTION


DOCUMENTS - ISSUED FOR BIDDING 1/22/2023

TITLE
PHASE 2 FOURTH
FLOOR PLUMBING
DEMOLITION & NEW
PLANS

P102.4 TRUE NORTH

Ν


PLAN NORTH

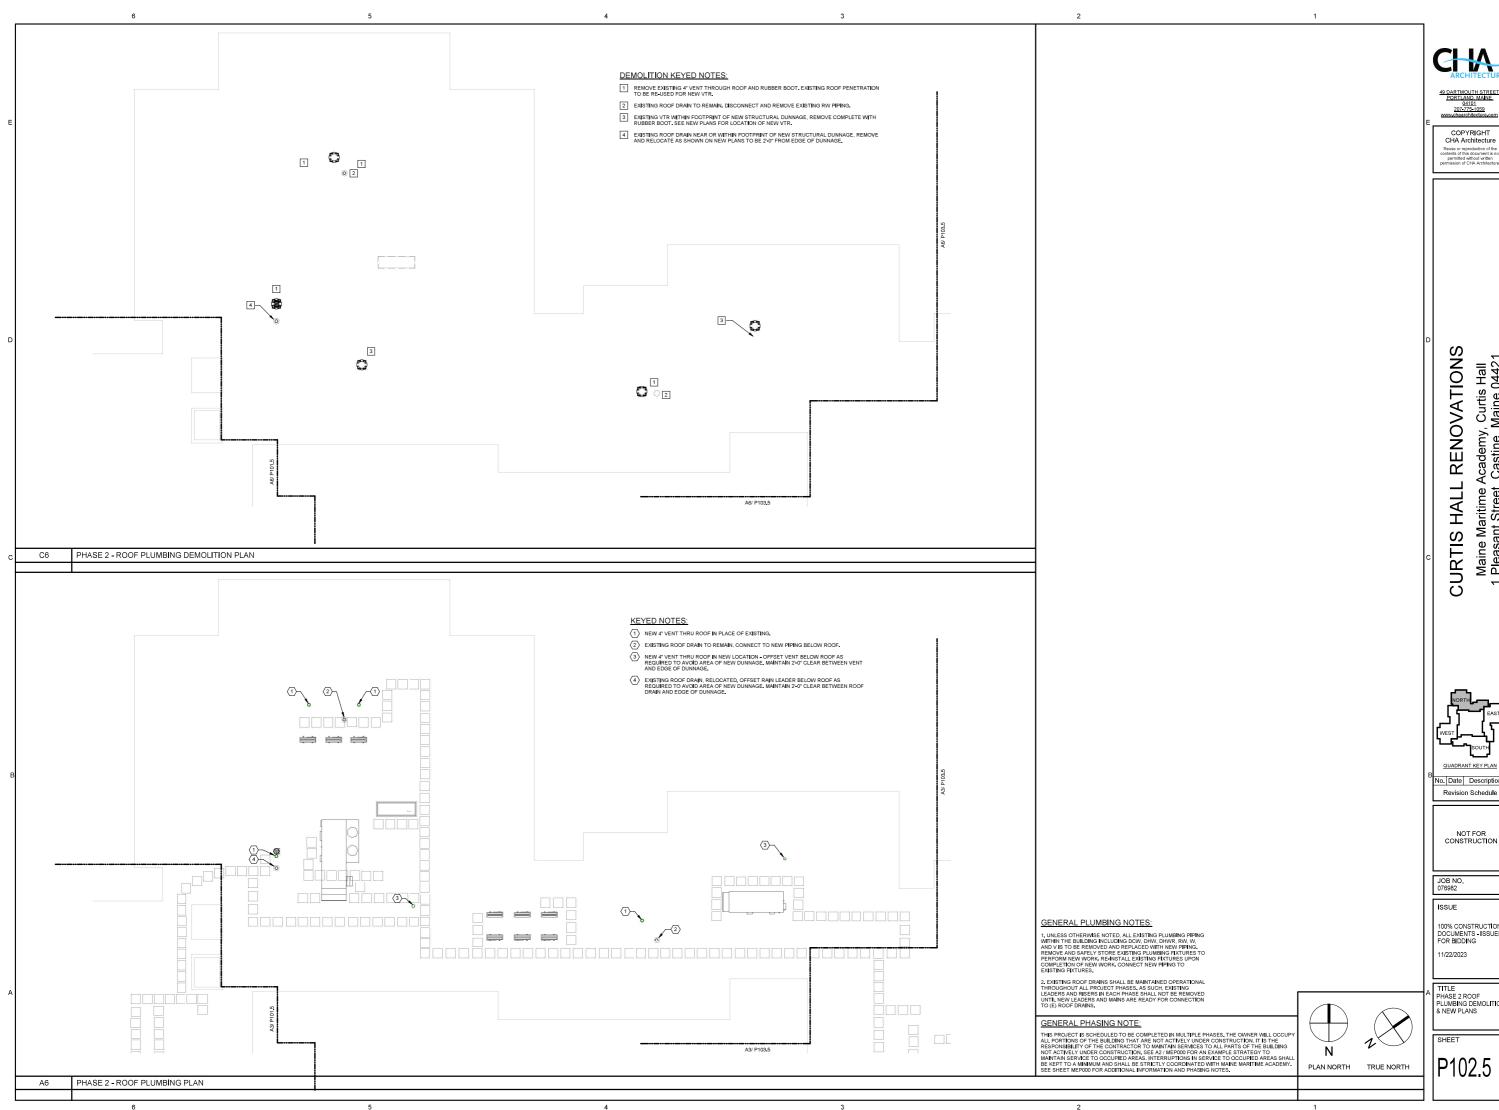

Maine Maritime Academy, Curtis Hall Pleasant Street, Castine, Maine 04421

100% CONSTRUCTION DOCUMENTS - ISSUED FOR BIDDING

TITLE
PHASE 2 ROOF
PLUMBING DEMOLITION
& NEW PLANS

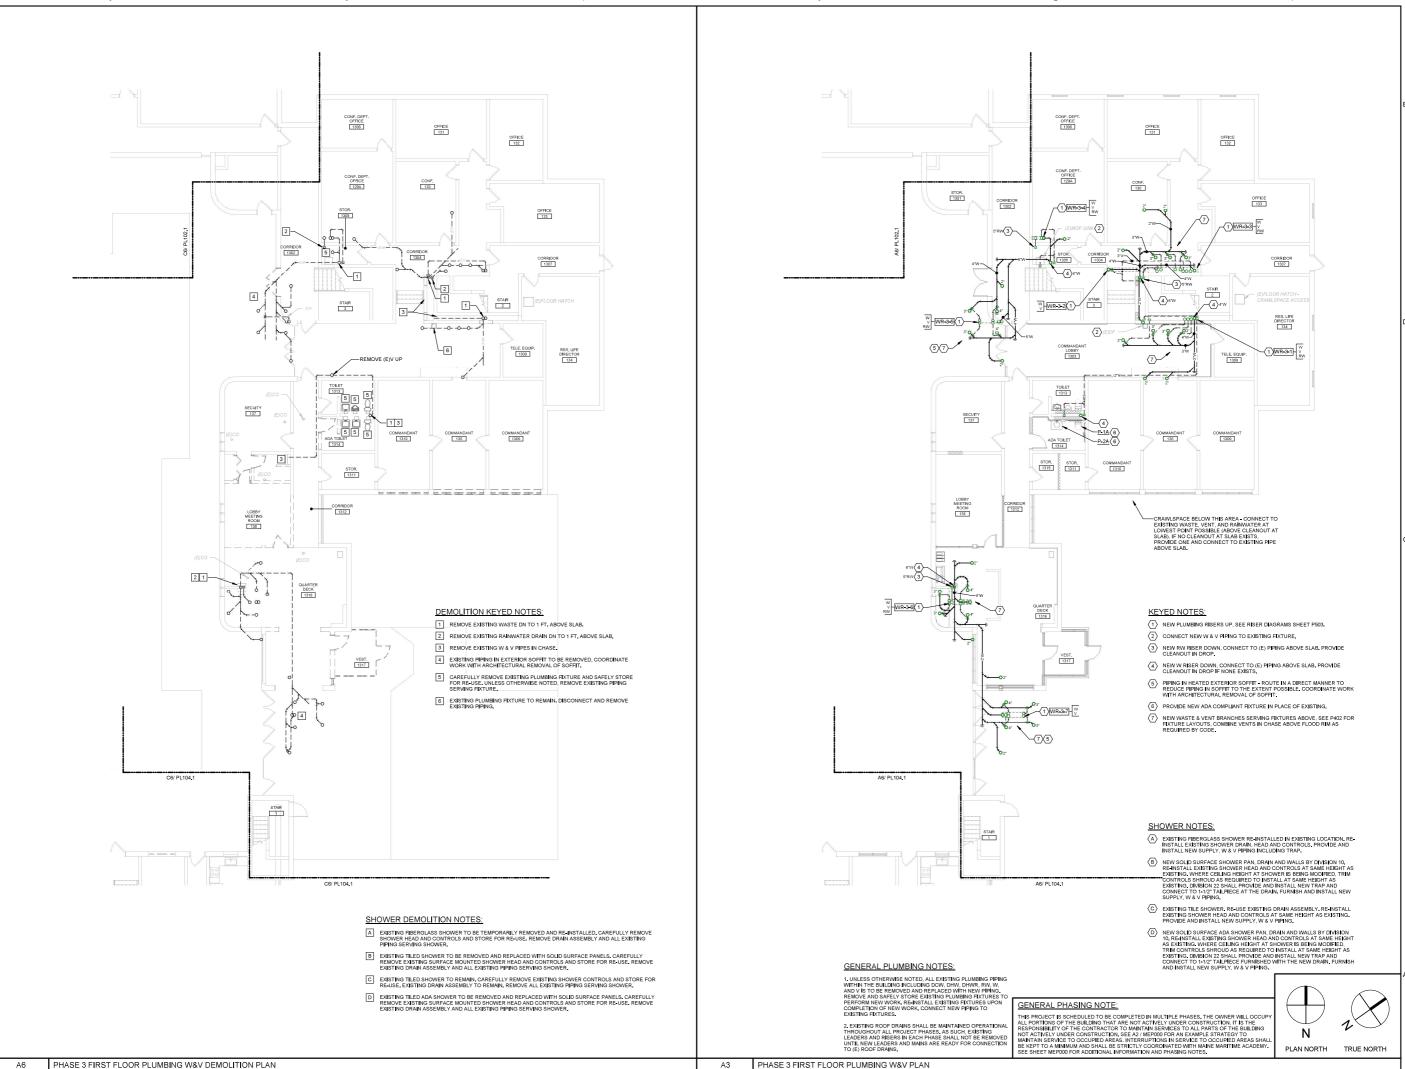

Reuse or reproduction of the ontents of this document is no permitted without written ermission of CHA Architectur

RENOVATIONS Maine Maritime Academy, Curtis Hall Pleasant Street, Castine, Maine 0442' **CURTIS HALL**

QUADRANT KEY PLAN

No. Date Description Revision Schedule

NOT FOR


JOB NO. 076982

ISSUE

100% CONSTRUCTION DOCUMENTS - ISSUED FOR BIDDING

11/22/2023

TITLE
PHASE 3 FIRST FLOOR
PLUMBING W&V
DEMOLITION & NEW
PLANS

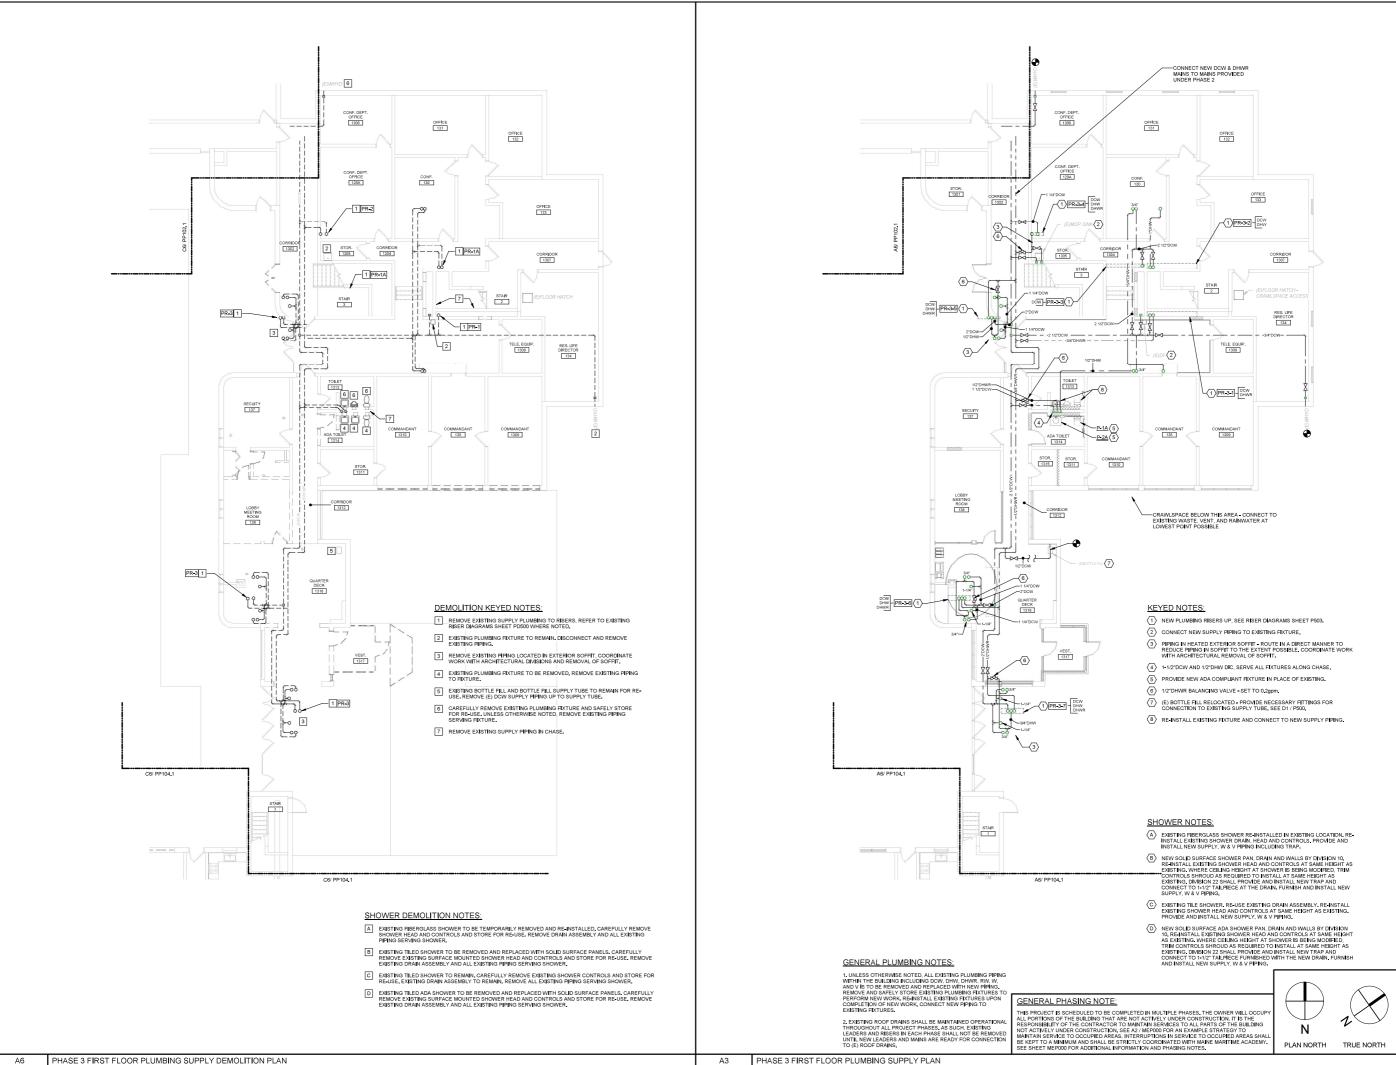

RENOVATIONS

Academy, Curtis Hall Castine, Maine 0442 **CURTIS HALL** Maine Maritime A

QUADRANT KEY PLAN

No. Date Description Revision Schedule

NOT FOR

JOB NO. 076982

ISSUE


100% CONSTRUCTION DOCUMENTS - ISSUED FOR BIDDING 11/22/2023

TITLE
PHASE 3 FIRST FLOOR
PLUMBING SUPPLY
DEMOLITION & NEW
PLANS

PP103.1

PHASE 3 FIRST FLOOR PLUMBING SUPPLY PLAN

A3

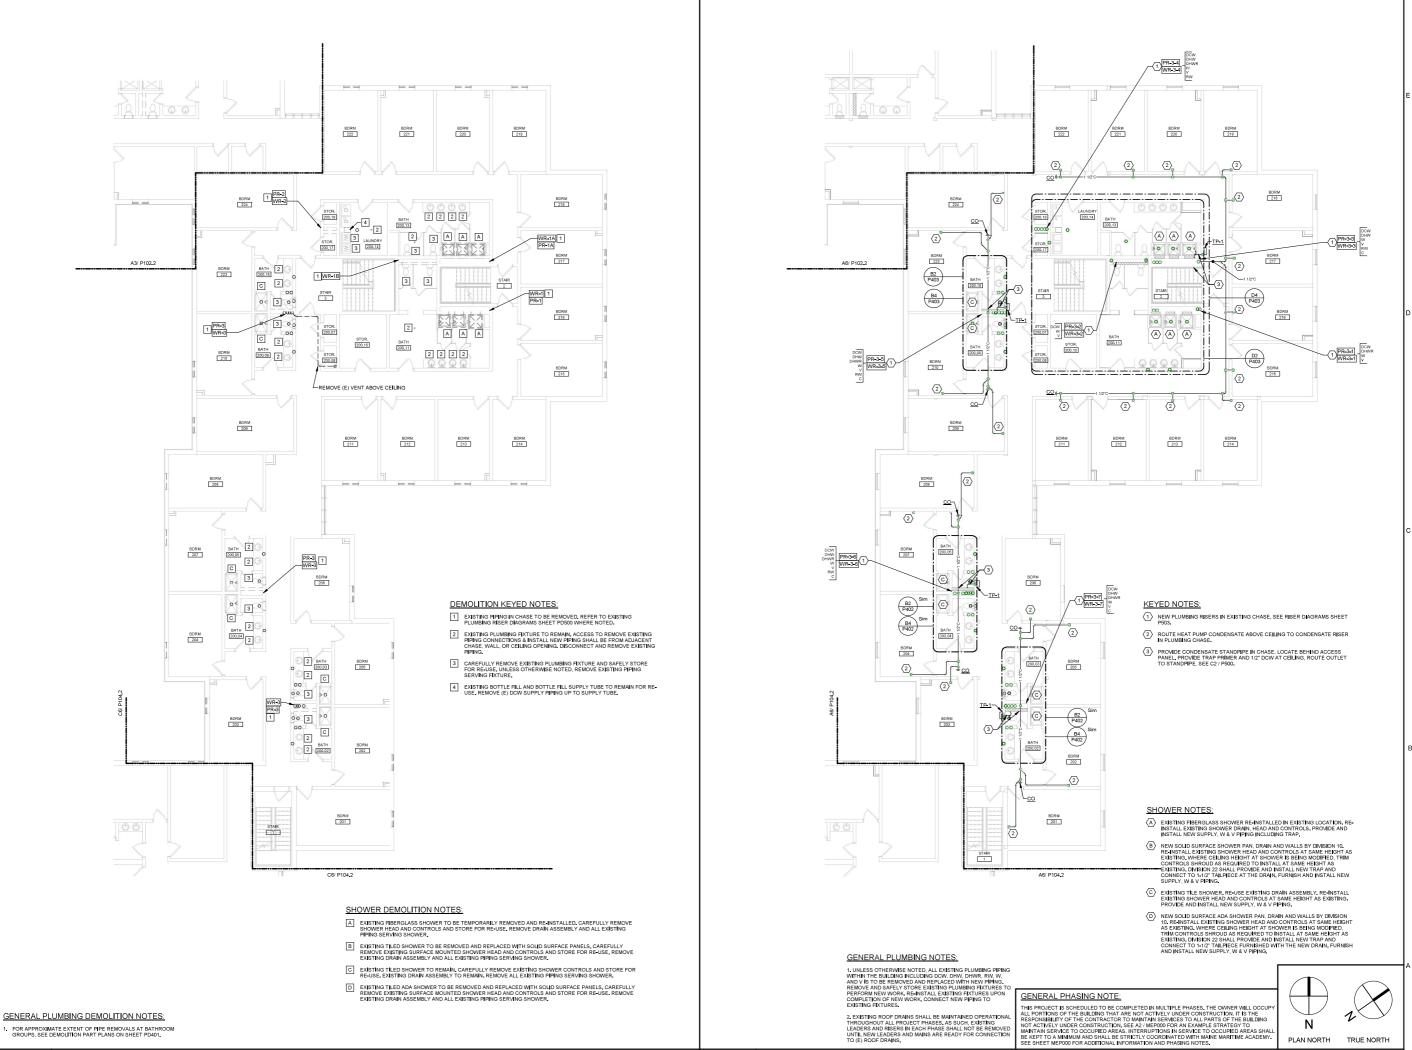

Reuse or reproduction of the ontents of this document is no permitted without written ermission of CHA Architectur

RENOVATIONS Academy, Curtis Hall , Castine, Maine 0442

CURTIS HALL Maine Maritime, Pleasant Street,

QUADRANT KEY PLAN No. Date Description

Revision Schedule

NOT FOR


JOB NO. 076982

ISSUE

100% CONSTRUCTION DOCUMENTS - ISSUED FOR BIDDING

1/22/2023

TITLE
PHASE 3 SECOND
FLOOR PLUMBING
DEMOLITION & NEW
PLANS

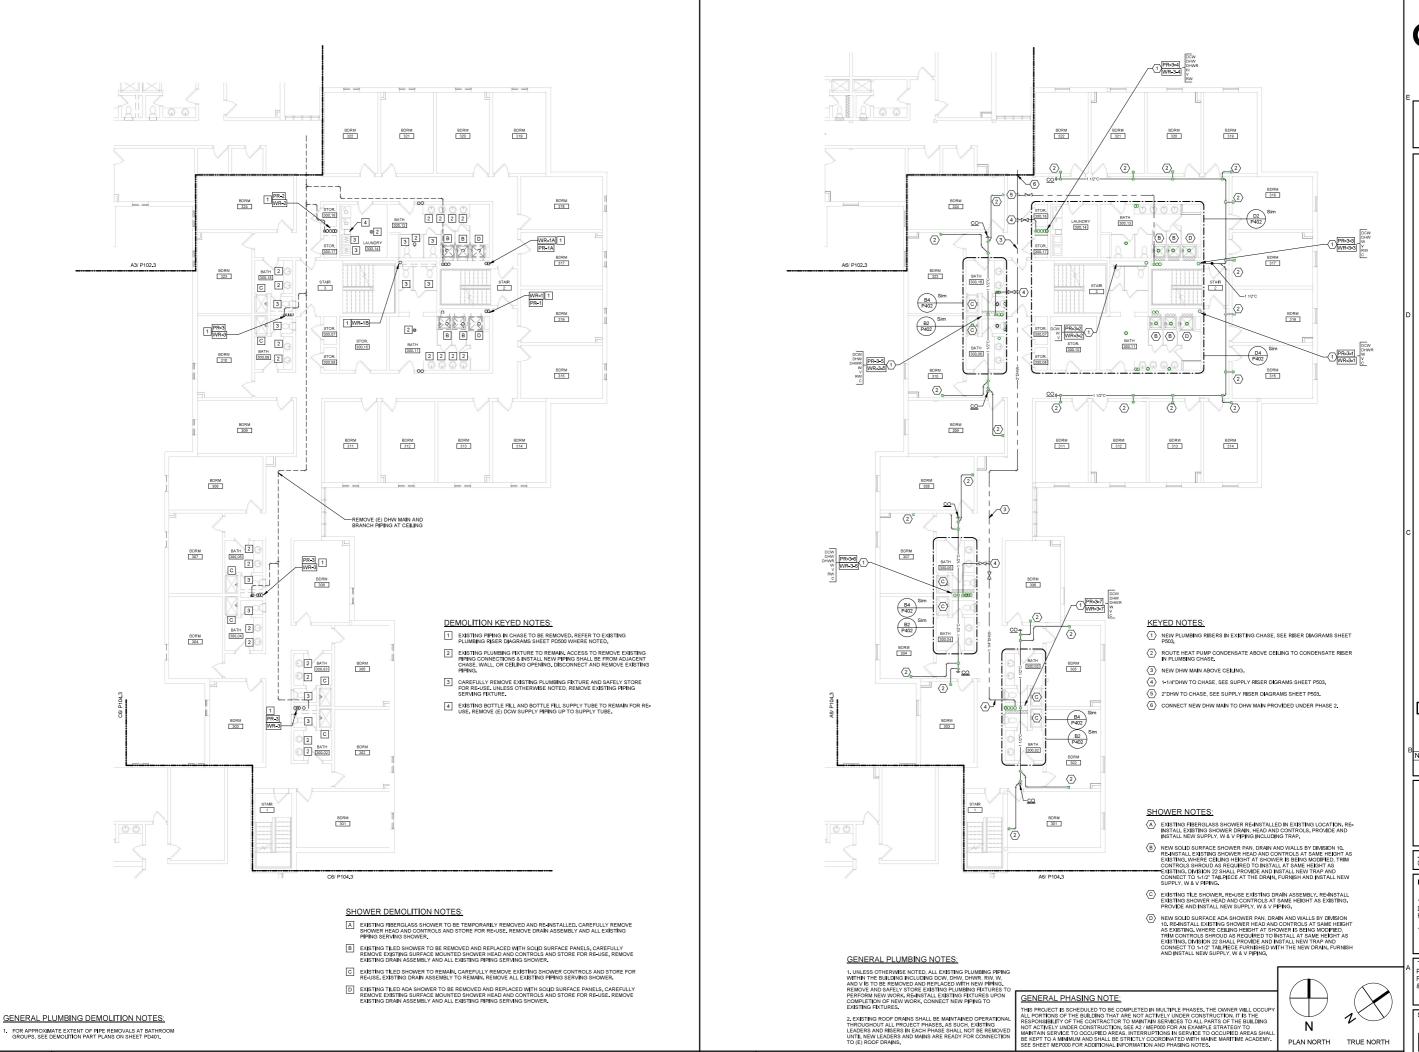

PHASE 3 THIRD FLOOR PLUMBING PLAN

A3

PHASE 3 THIRD FLOOR PLUMBING DEMOLITION PLAN

COPYRIGHT CHA Architecture

Reuse or reproduction of the ontents of this document is no permitted without written ermission of CHA Architectur

RENOVATIONS

Maine Maritime Academy, Curtis Hall Pleasant Street, Castine, Maine 0442' **CURTIS HALL**

QUADRANT KEY PLAN

No. Date Description Revision Schedule

NOT FOR


JOB NO. 076982

ISSUE

100% CONSTRUCTION DOCUMENTS - ISSUED FOR BIDDING 1/22/2023

TITLE
PHASE 3 THIRD FLOOR
PLUMBING DEMOLITION
& NEW PLANS

SHEET

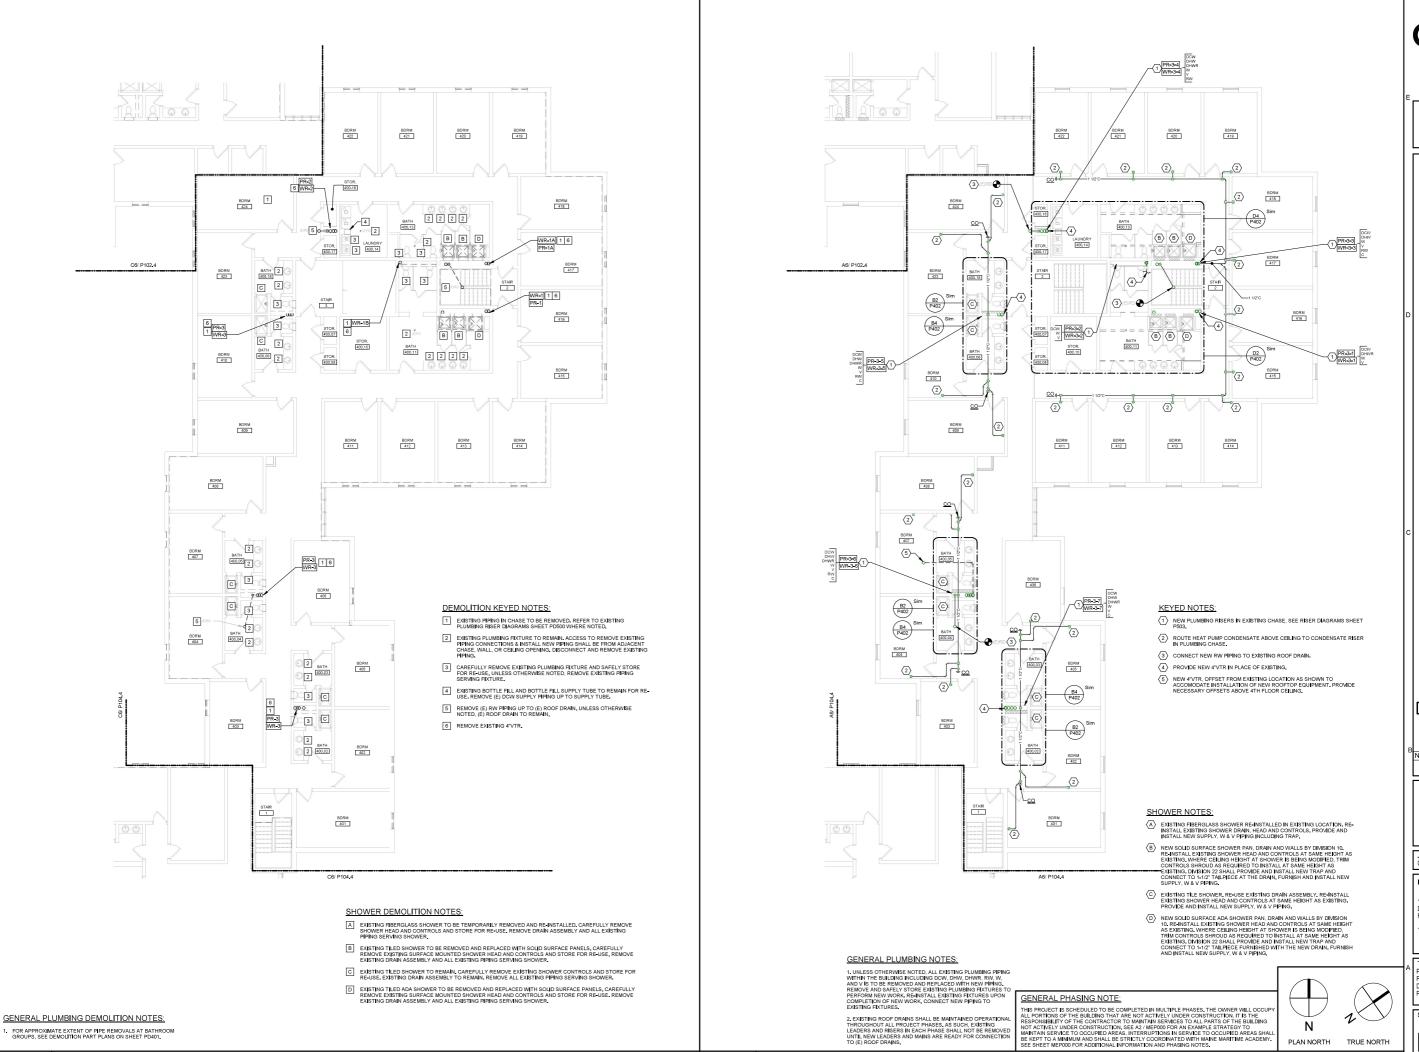

PHASE 3 FOURTH FLOOR PLUMBING PLAN

A3

PHASE 3 FOURTH FLOOR PLUMBING DEMOLITION PLAN

COPYRIGHT CHA Architecture

Reuse or reproduction of the ontents of this document is no permitted without written ermission of CHA Architectur

RENOVATIONS

Academy, Curtis Hall , Castine, Maine 0442 **CURTIS HALL** Maine Maritime, Pleasant Street,

QUADRANT KEY PLAN No. Date Description

Revision Schedule


NOT FOR

JOB NO. 076982

ISSUE

100% CONSTRUCTION DOCUMENTS - ISSUED FOR BIDDING 11/22/2023

TITLE
PHASE 3 FOURTH
FLOOR PLUMBING
DEMOLITION & NEW
PLANS

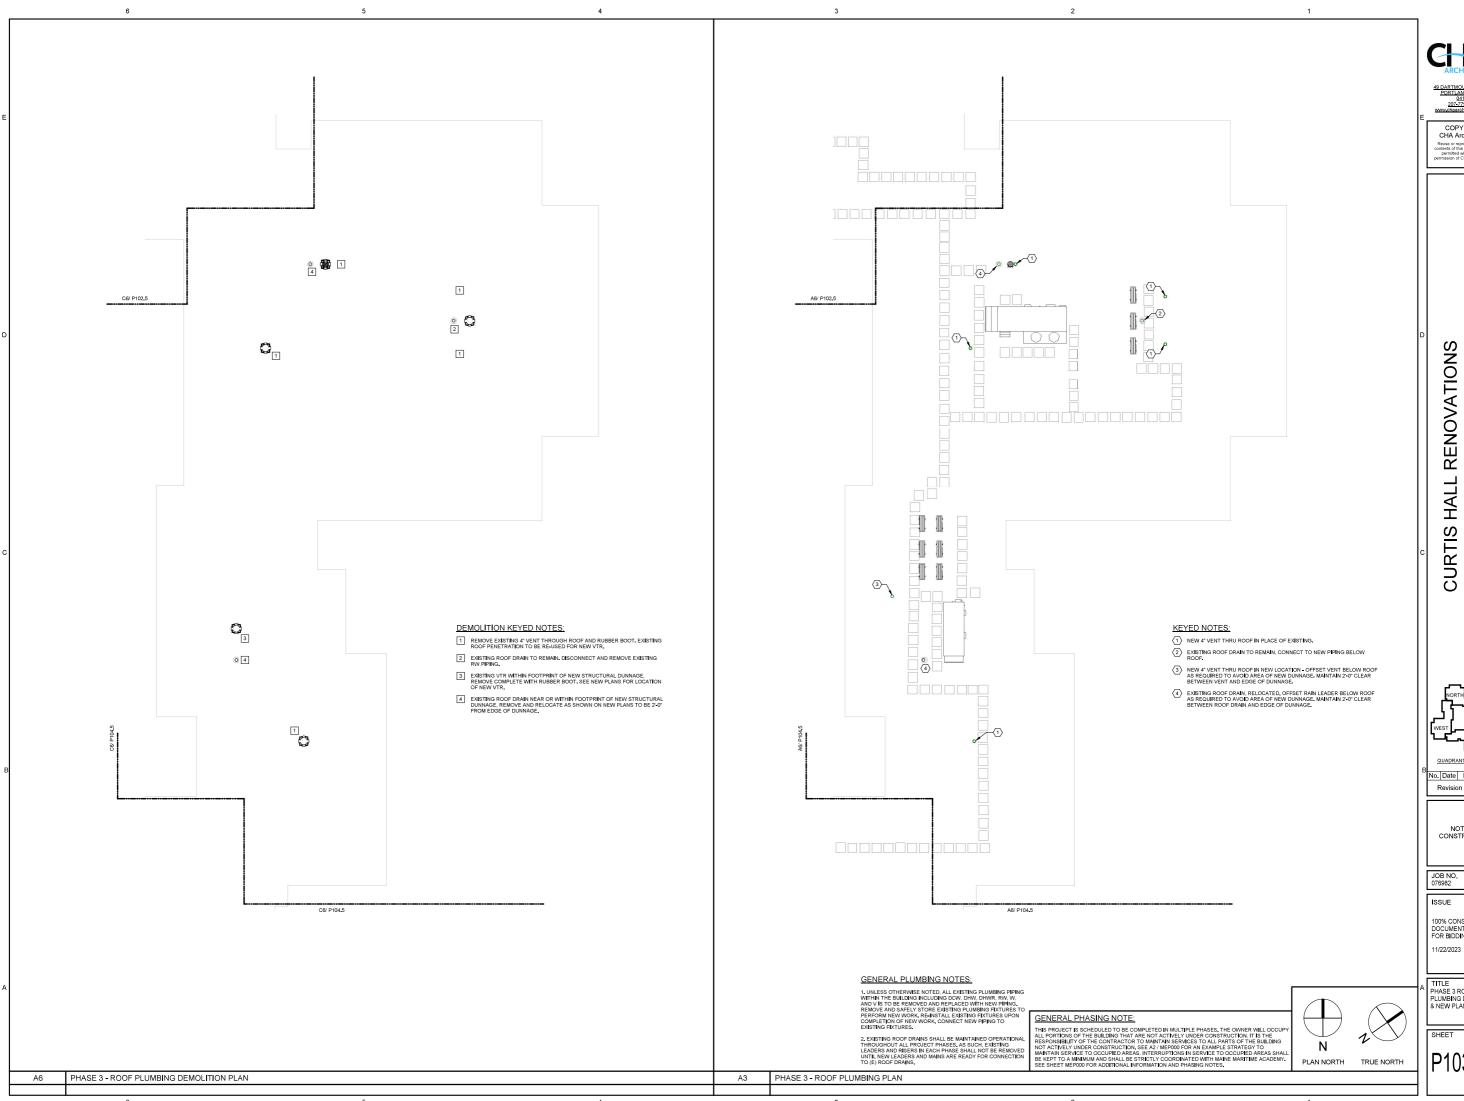


Maine Maritime Academy, Curtis Hall Pleasant Street, Castine, Maine 04421

No. Date Description Revision Schedule

NOT FOR CONSTRUCTION

100% CONSTRUCTION DOCUMENTS - ISSUED FOR BIDDING

TITLE
PHASE 3 ROOF
PLUMBING DEMOLITION
& NEW PLANS

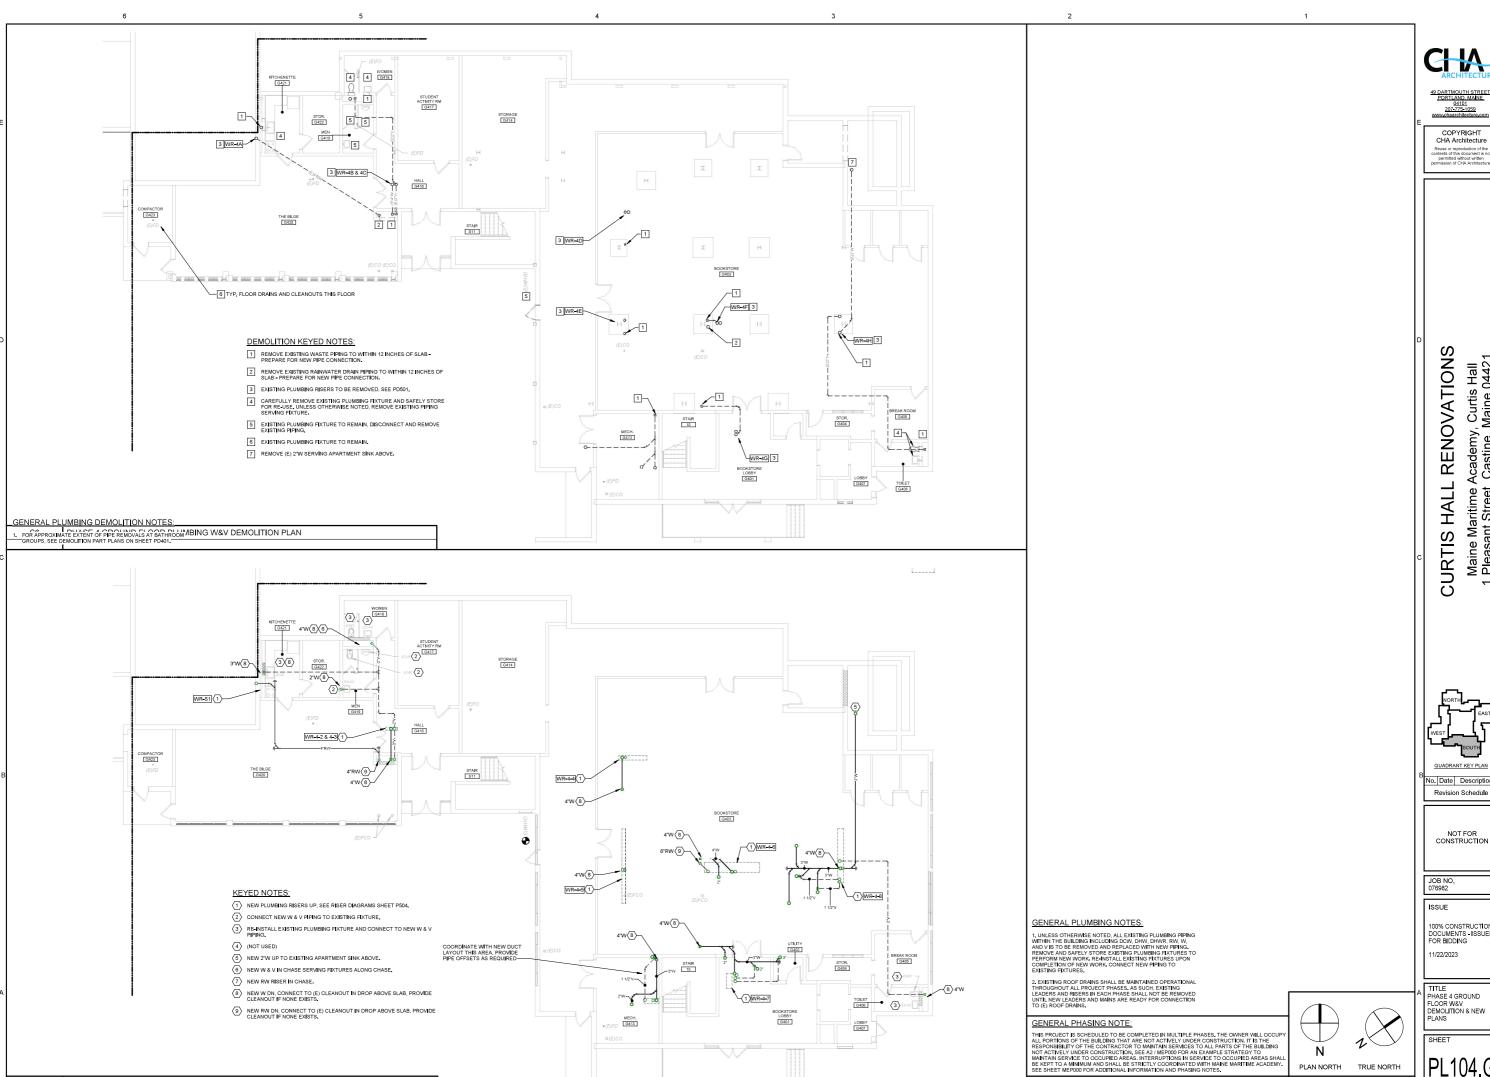

PHASE 4 GROUND FLOOR PLUMBING W&V PLAN

COPYRIGHT CHA Architecture


Maine Maritime Academy, Curtis Hall Pleasant Street, Castine, Maine 04421

100% CONSTRUCTION DOCUMENTS - ISSUED FOR BIDDING

TITLE
PHASE 4 GROUND
FLOOR W&V
DEMOLITION & NEW
PLANS

PL104.G

PLAN NORTH

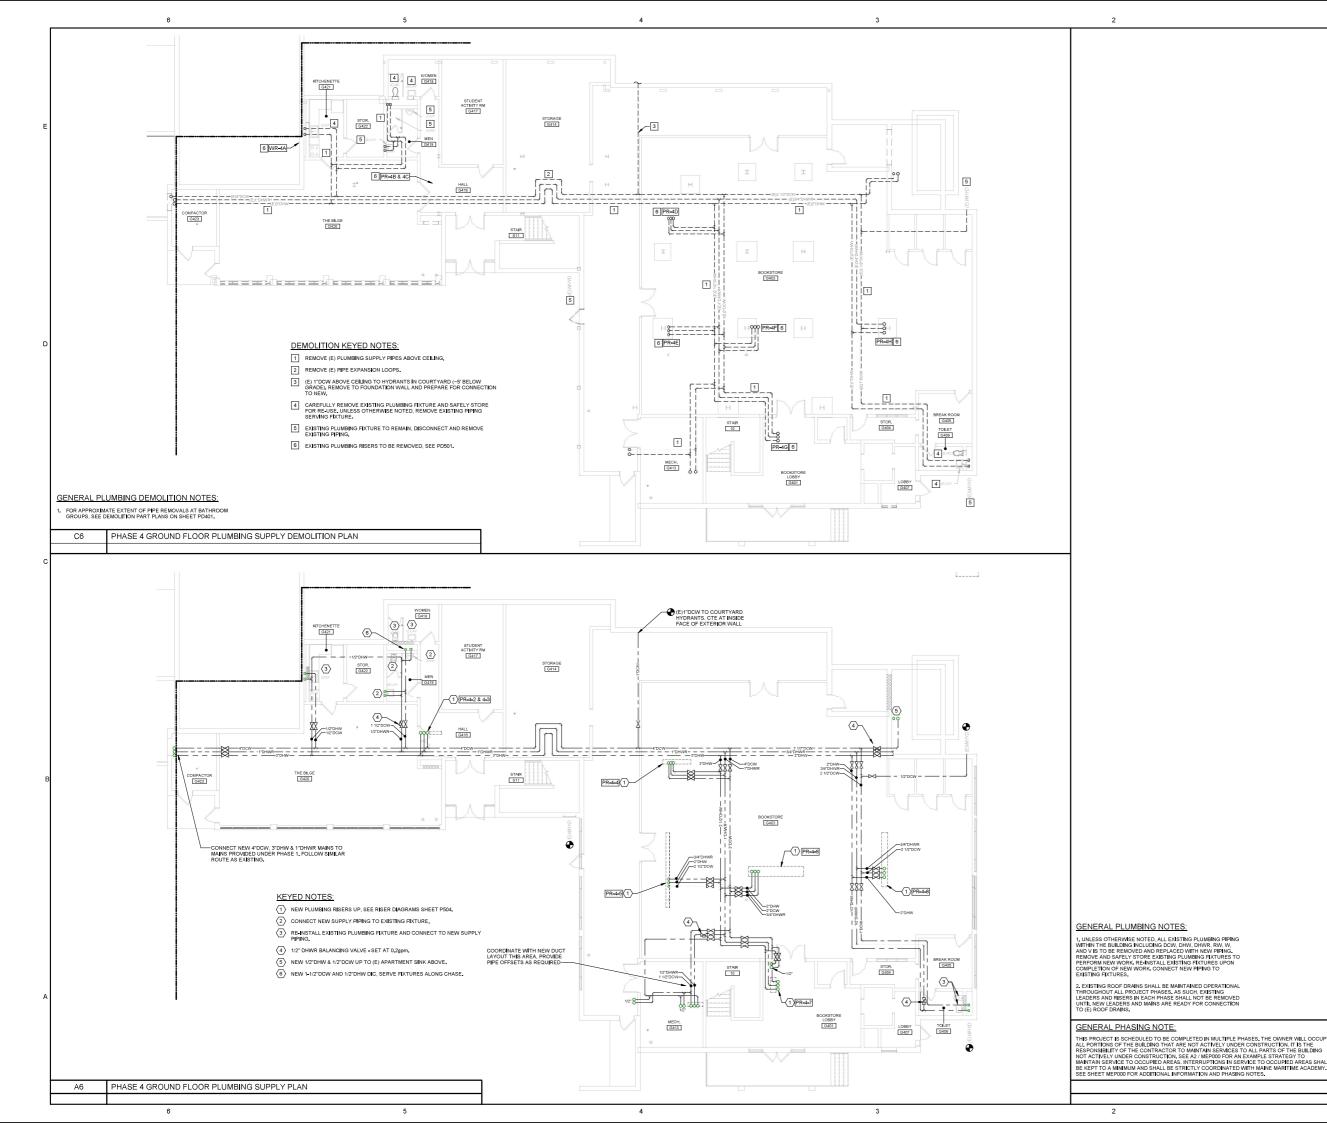

CURTIS HALL RENOVATIONS Maine Maritime Academy, Curtis Hall Pleasant Street, Castine, Maine 04421



No. Date Description

Revision Schedule

NOT FOR CONSTRUCTION

JOB NO. 076982

ISSUE


100% CONSTRUCTION DOCUMENTS - ISSUED FOR BIDDING 11/22/2023

TITLE
PHASE 4 GROUND
FLOOR PLUMBING
SUPPLY DEMOLITION &
NEW PLANS

PP104.G

Ν

PLAN NORTH

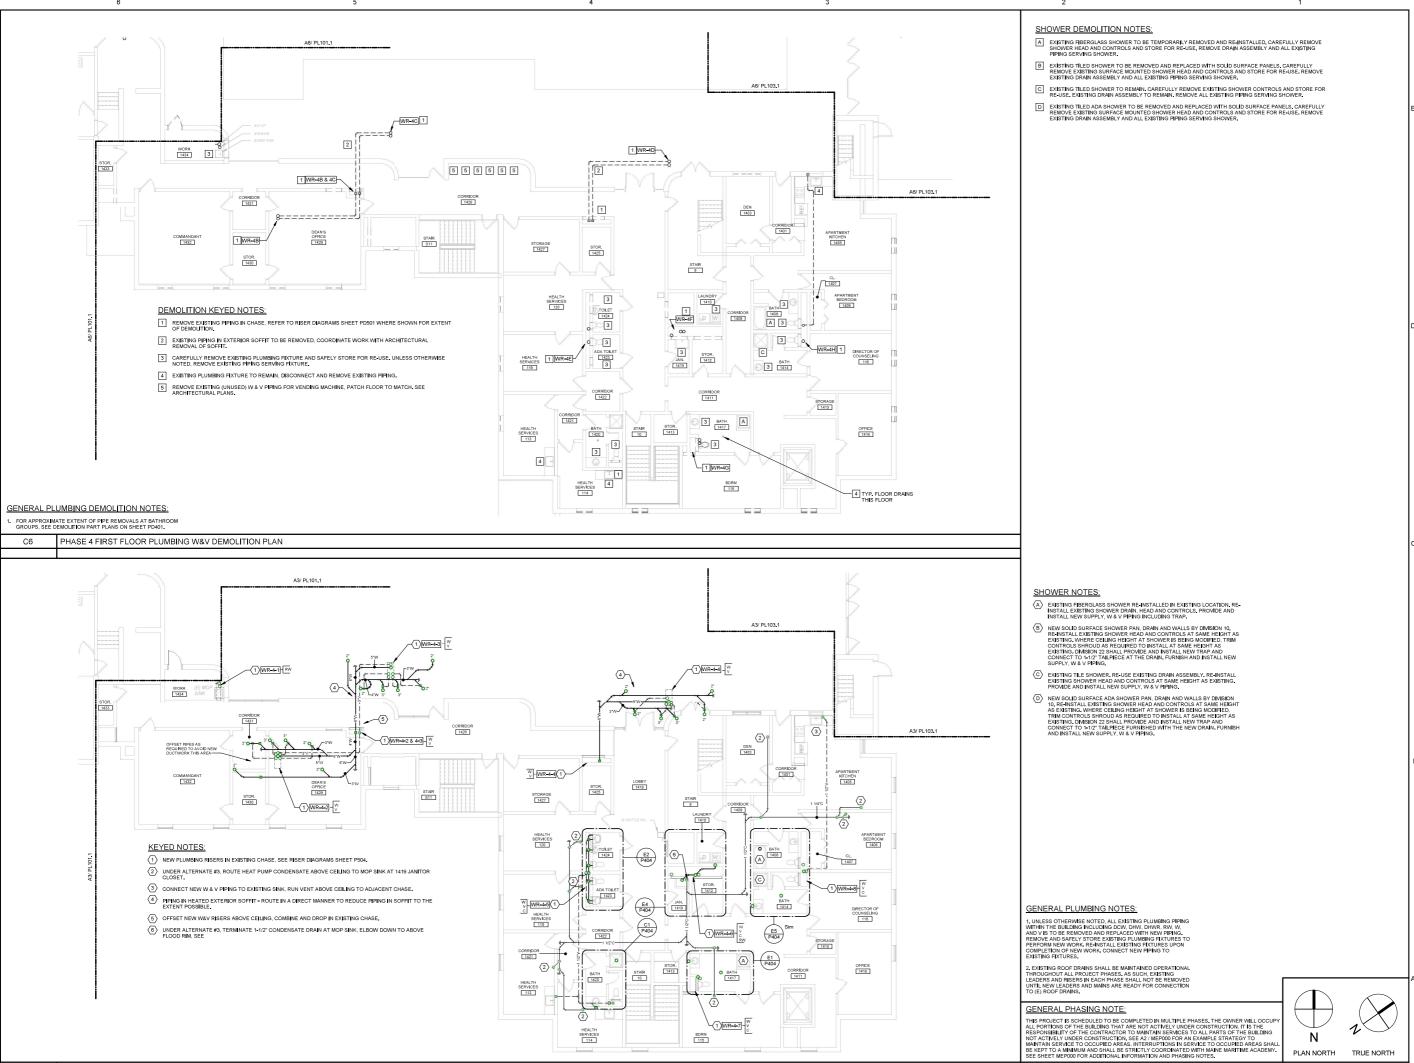

BDRM 115

HEALTH SERVICES

PHASE 4 FIRST FLOOR PLUMBING W&V PLAN

COPYRIGHT CHA Architecture

Reuse or reproduction of the ontents of this document is n permitted without written ermission of CHA Architectur

RENOVATIONS Academy, Curtis Hall Castine, Maine 0442 **CURTIS HALL**

Maine Maritime, Pleasant Street,

QUADRANT KEY PLAN

No. Date Description Revision Schedule

NOT FOR

JOB NO. 076982

ISSUE

100% CONSTRUCTION

DOCUMENTS - ISSUED FOR BIDDING 1/22/2023

TITLE
PHASE 4 FIRST FLOOR
PLUMBING W&V
DEMOLITION & NEW
PLANS

PL104.1

Ν

PLAN NORTH